



# BOILER ROOM REMOVAL PLAN

SCALE: 3/8" = 1

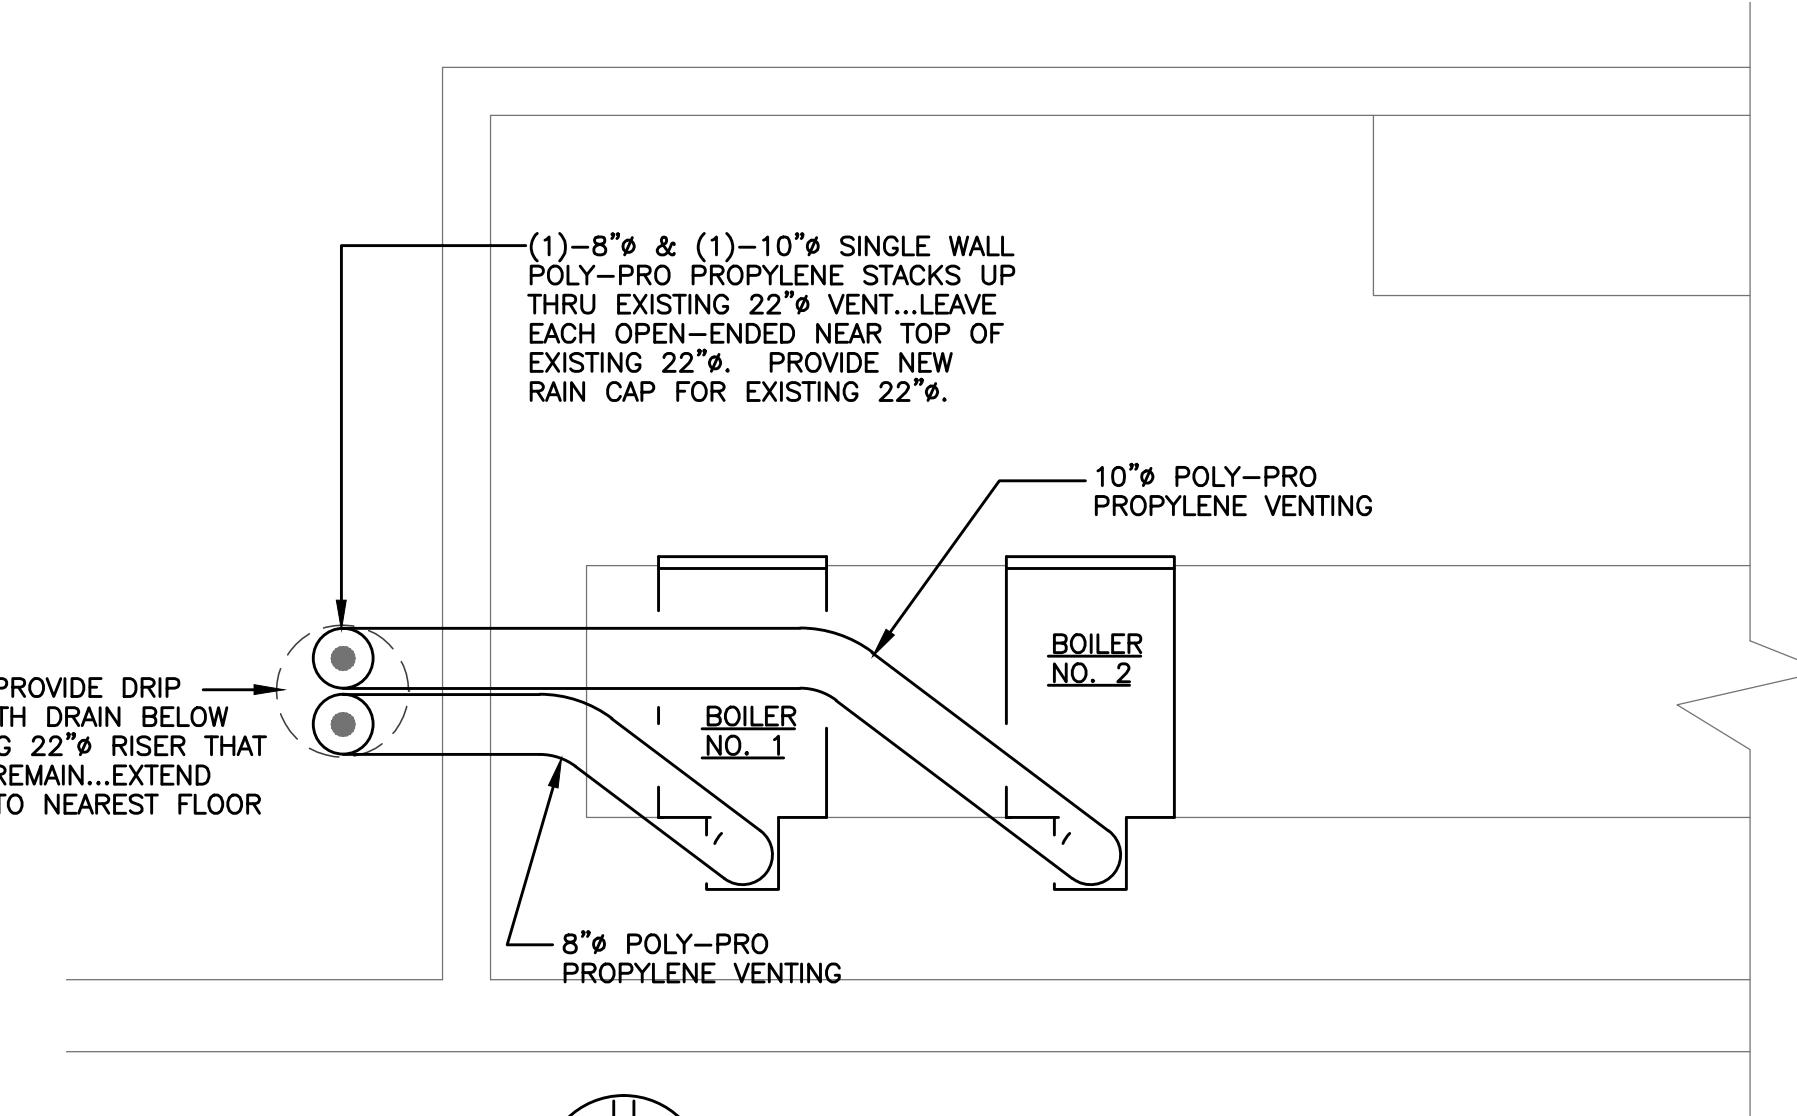

# BOILER VENTING PLAN

SCALE: 3/8" = 1'-0"

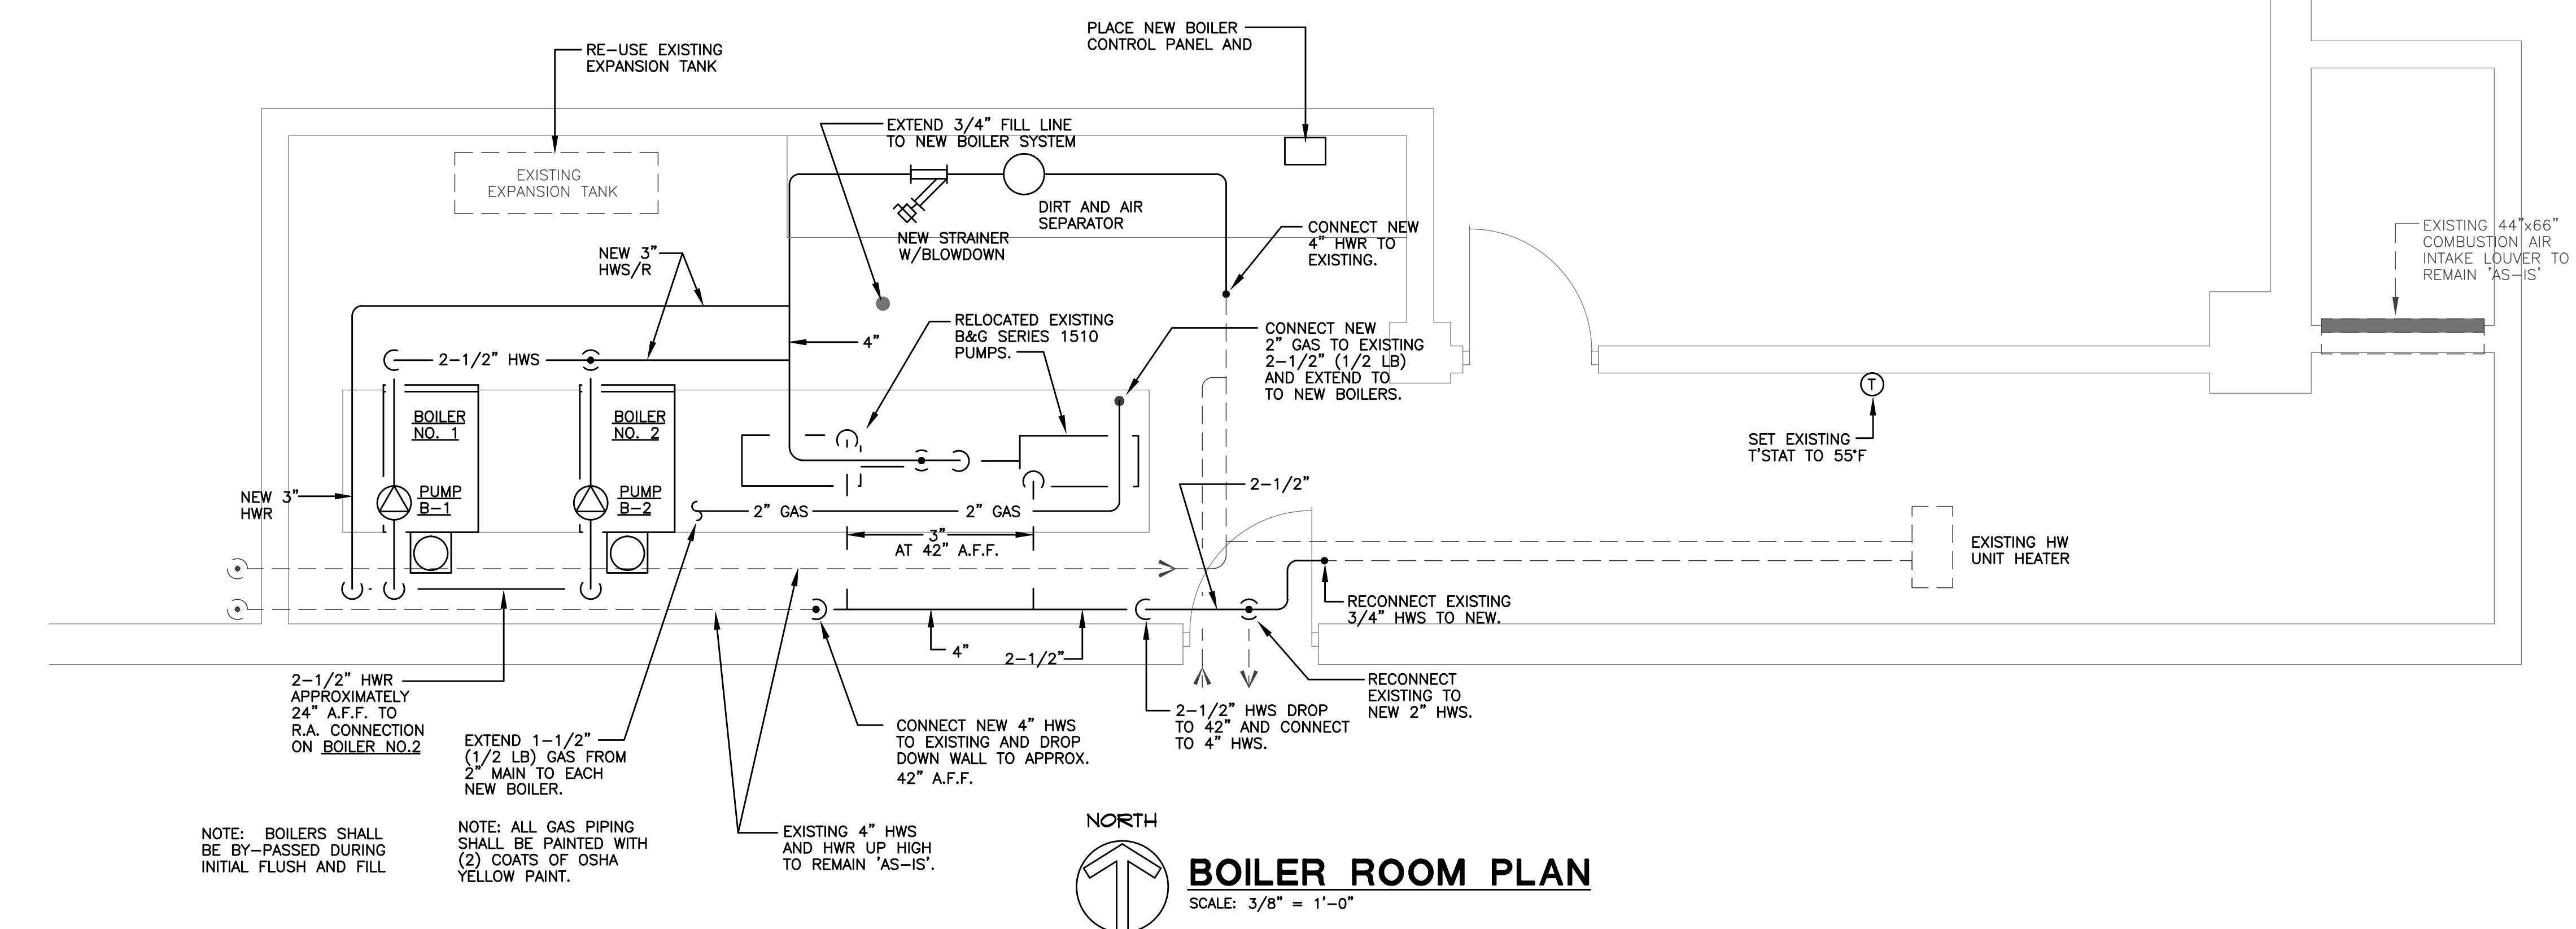

# BOILER ROOM PLAN

SCALE: 3/8" = 1'-0"

HOT WATER BOILER SCHEDULE																			
UNIT	FUEL TYPE	INPUT MBH	OUTPUT MBH	EFF. %	VENTING	VENT SIZE	COMB. AIR SIZE	ELECTRICAL			GAS TRAIN	GAS PRESS. REQUIRED	UTILITY GAS PRESS.	BURNER		RELIEF VALVE	MANUF.	MODEL	REMARKS
								CIRCUIT	VOLTS	PH.				TYPE	CONTROL				
1	NAT. GAS	750	712.5	95	SEALED COMBUSTION	8"Ø	6"Ø	15 AMP	120	1	U.L.	3.5-14" W.C.	(VERIFY)	POWER	MODULTING	30 PSI	PATTERON-KELLEY	MACH C750	OWNER TAX FREE ENTITY
2	NAT. GAS	900	846	94	SEALED COMBUSTION	10"Ø	6"Ø	15 AMP	120	1	U.L.	3.5-14" W.C.	(VERIFY)	POWER	MODULTING	30 PSI	PATTERON-KELLEY	MACH C900	OWNER TAX FREE ENTITY

NOTE: ALL PUMPS SHALL BE PURCHASED BY THE OWNER BUT THRU THE HVAC CONTRACTOR. HVAC CONTRACTOR SHALL INCLUDE THE COST OF PUMPS IN THEIR BIDS KEEPING IN MIND THAT THE OWNER IS A TAX FREE ENTITY.

213 Stroebe Rd.  
Appleton, Wisconsin 54914  
Phone: 920-730-7473  
email: [jferg@new.rr.com](mailto:jferg@new.rr.com)

213 Stroebe Rd.  
Appleton, Wisconsin 54914  
Phone: 920-730-7473  
email: jferg@new.rr.com

**ALL**

OUAGAVILLE COUNTY AIRPORT |  
1989 TERMINAL BUILDING  
BOILER REPLACEMENT  
OF GREENVILLE

06-24-13

1309

SHEET NO. \_\_\_\_\_

H2