
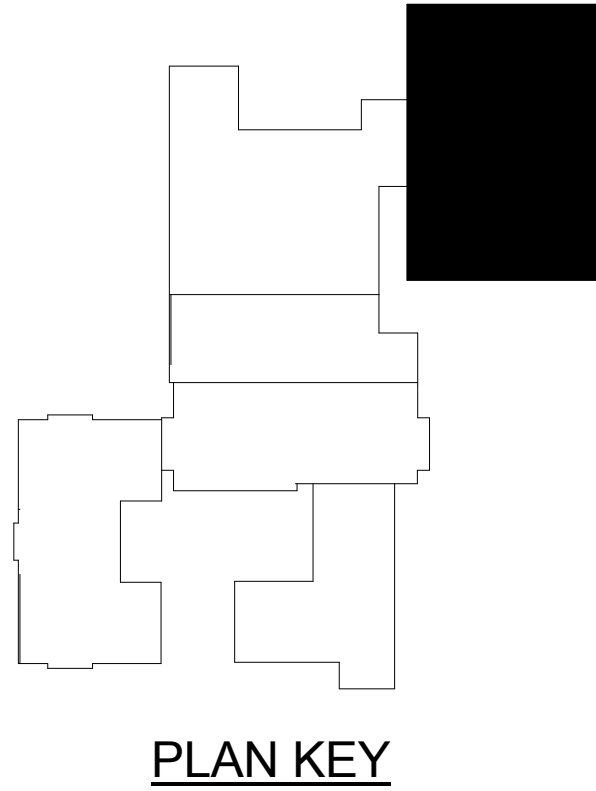


1 LEVEL 780.00 EM LIGHTING PHOTOMETRIC PLAN-JUSTICE CENTER
Scale: 1/8" = 1'-0"

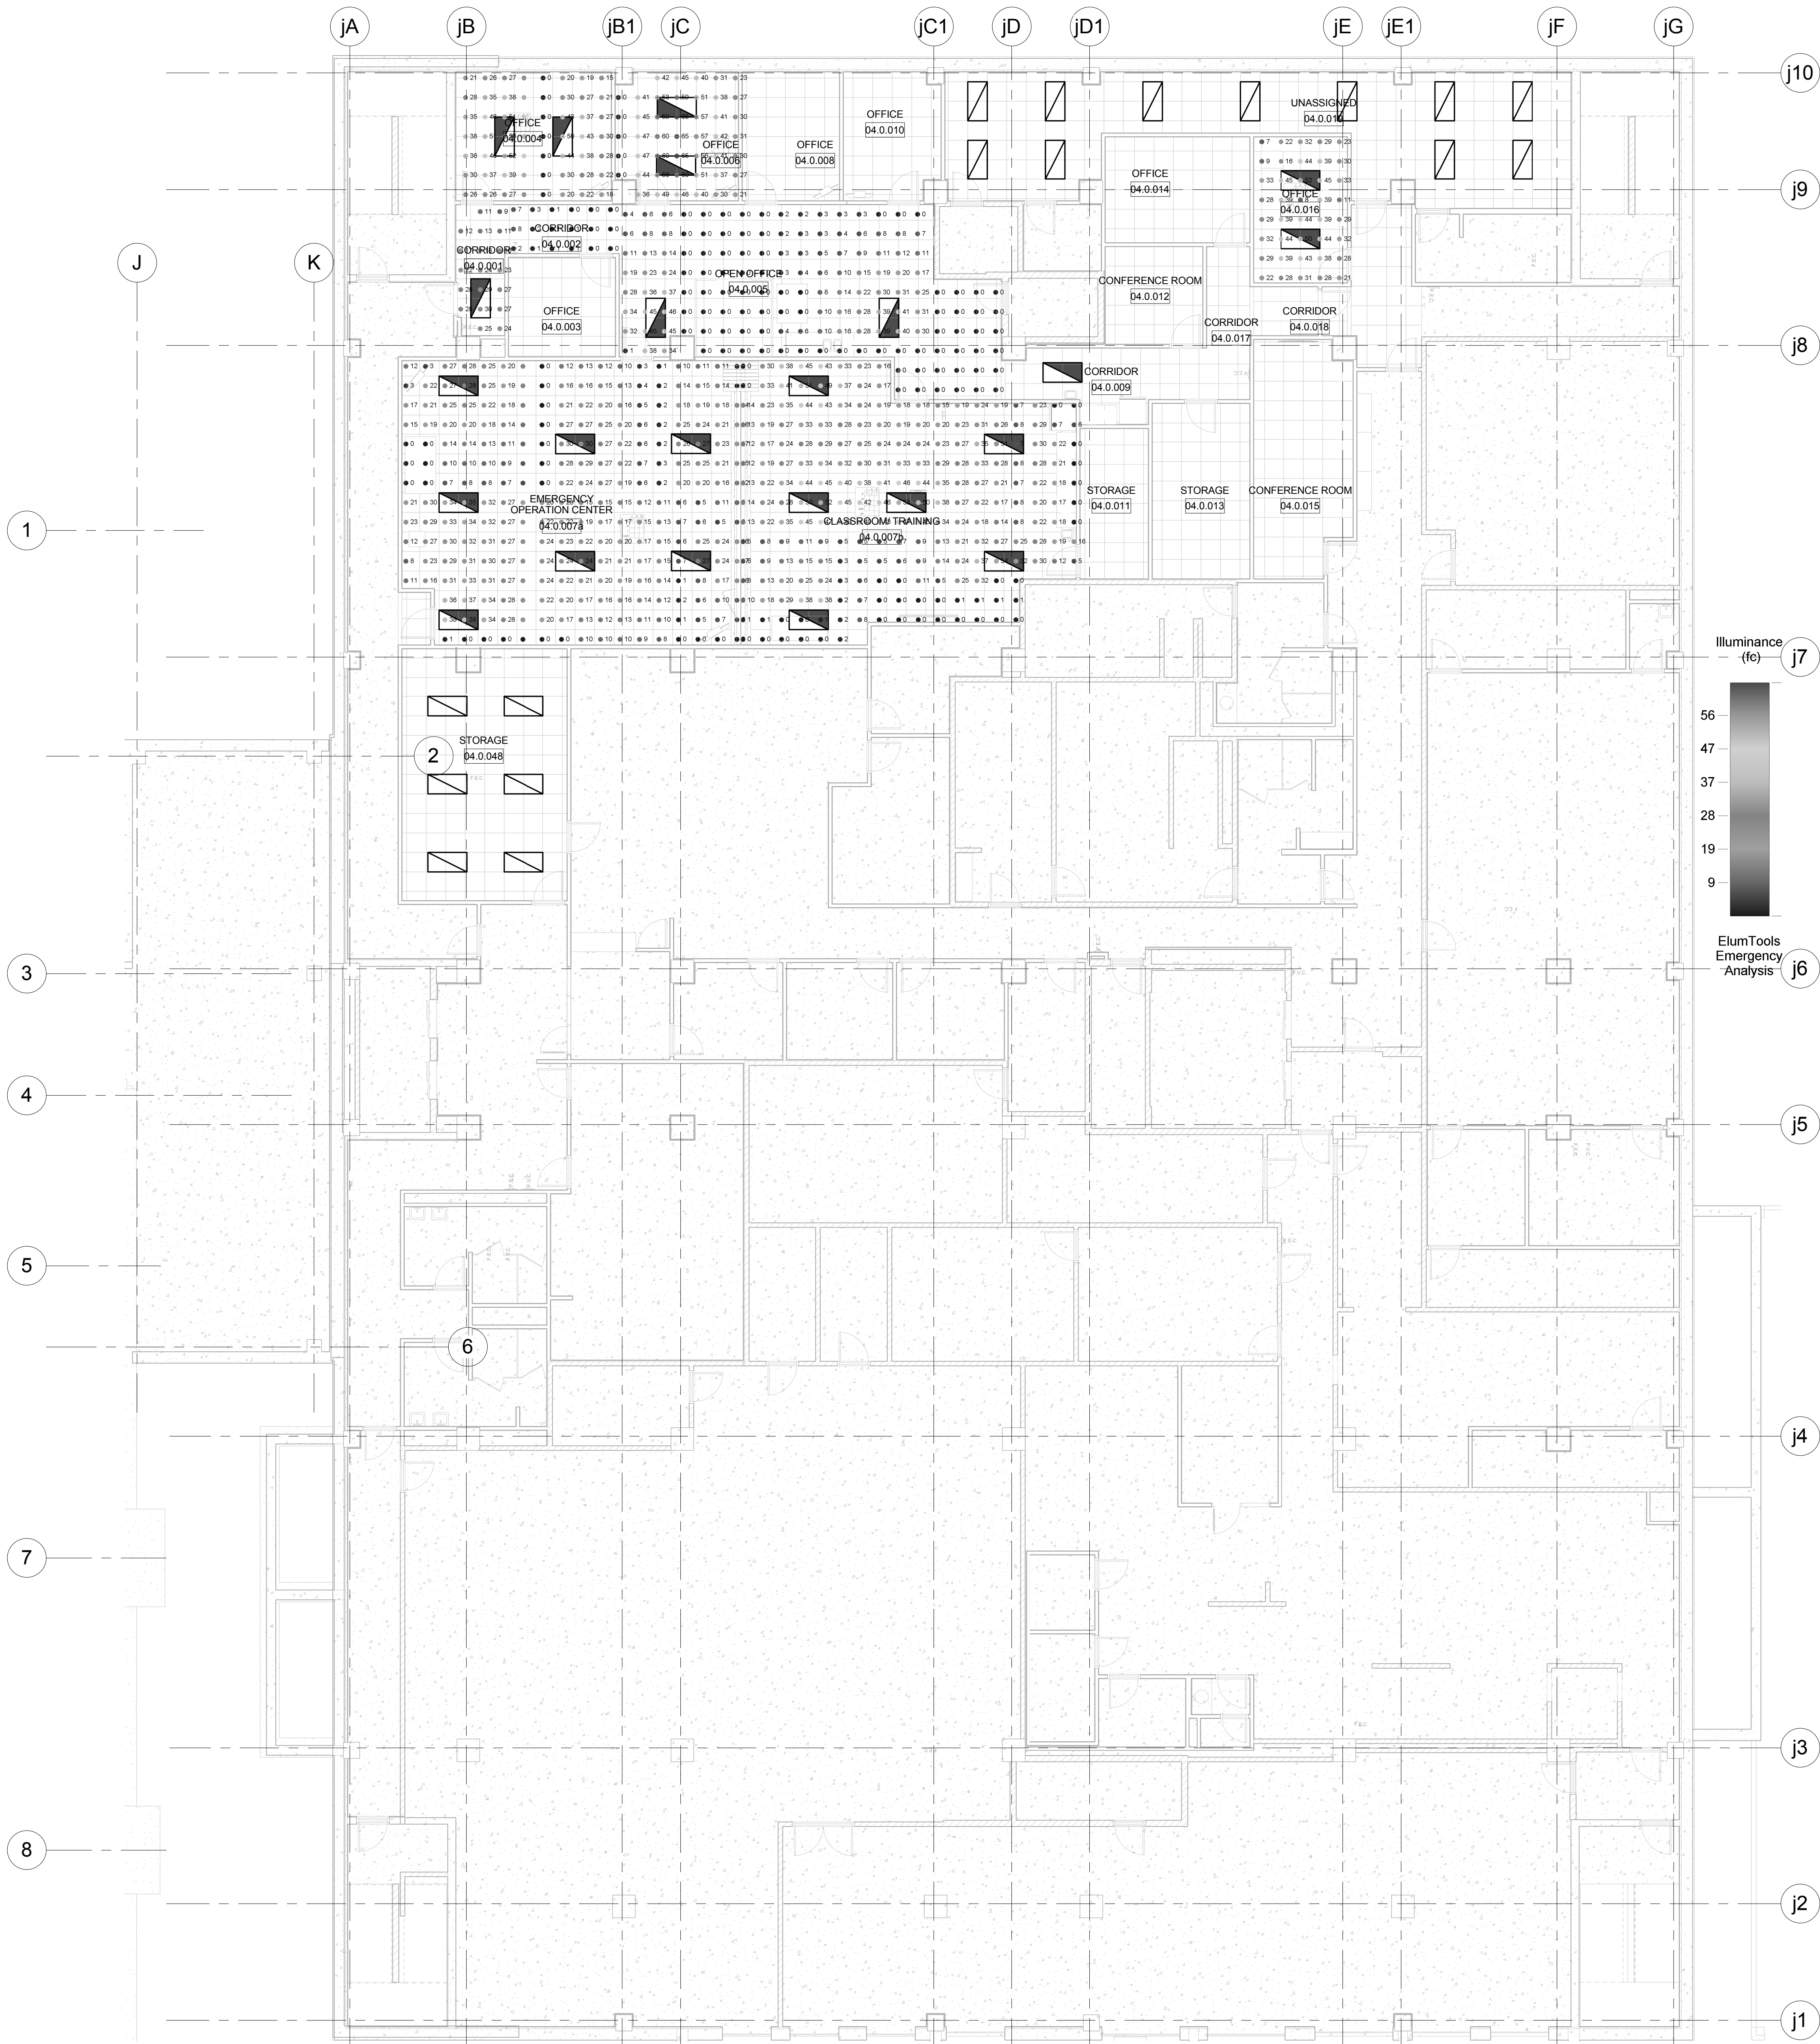

ALTERATION / ADDITION
OUTAGAMIE COUNTY ADMINISTRATION CENTER
S. WALNUT & W. 8TH, APPLETON WI 54911
LEVEL 780.00 EM LIGHTING PHOTOMETRIC PLAN-JUSTICE CENTER

DESIGNED	DRAWN
CEH	MAL
PROJECT NO.	
00002-61600160	
DATE	
MARCH 3, 2017	
SHEET NO.	

EM230

McMahon provides this drawing as instruments of service. All information is to be used for the project and not for any other purpose. The Client acknowledges that McMahon is not responsible for the accuracy of the information provided by the Client. McMahon is not responsible for the accuracy of the information provided by the Client. McMahon is not responsible for the accuracy of the information provided by the Client.


McMAHON
ENGINEERS ARCHITECTS
1025 VERNON AVENUE
MILWAUKEE, WI 53212
Tel: (414) 754-4200 Fax: (414) 754-4284
www.mcmahon.com



2 LEVEL 820.00 EM LIGHTING PHOTOMETRIC PLAN-CAB
Scale: 1/8" = 1'-0"



1 LEVEL 790.00 EM LIGHTING PHOTOMETRIC PLAN-CAB
Scale: 1/8" = 1'-0"

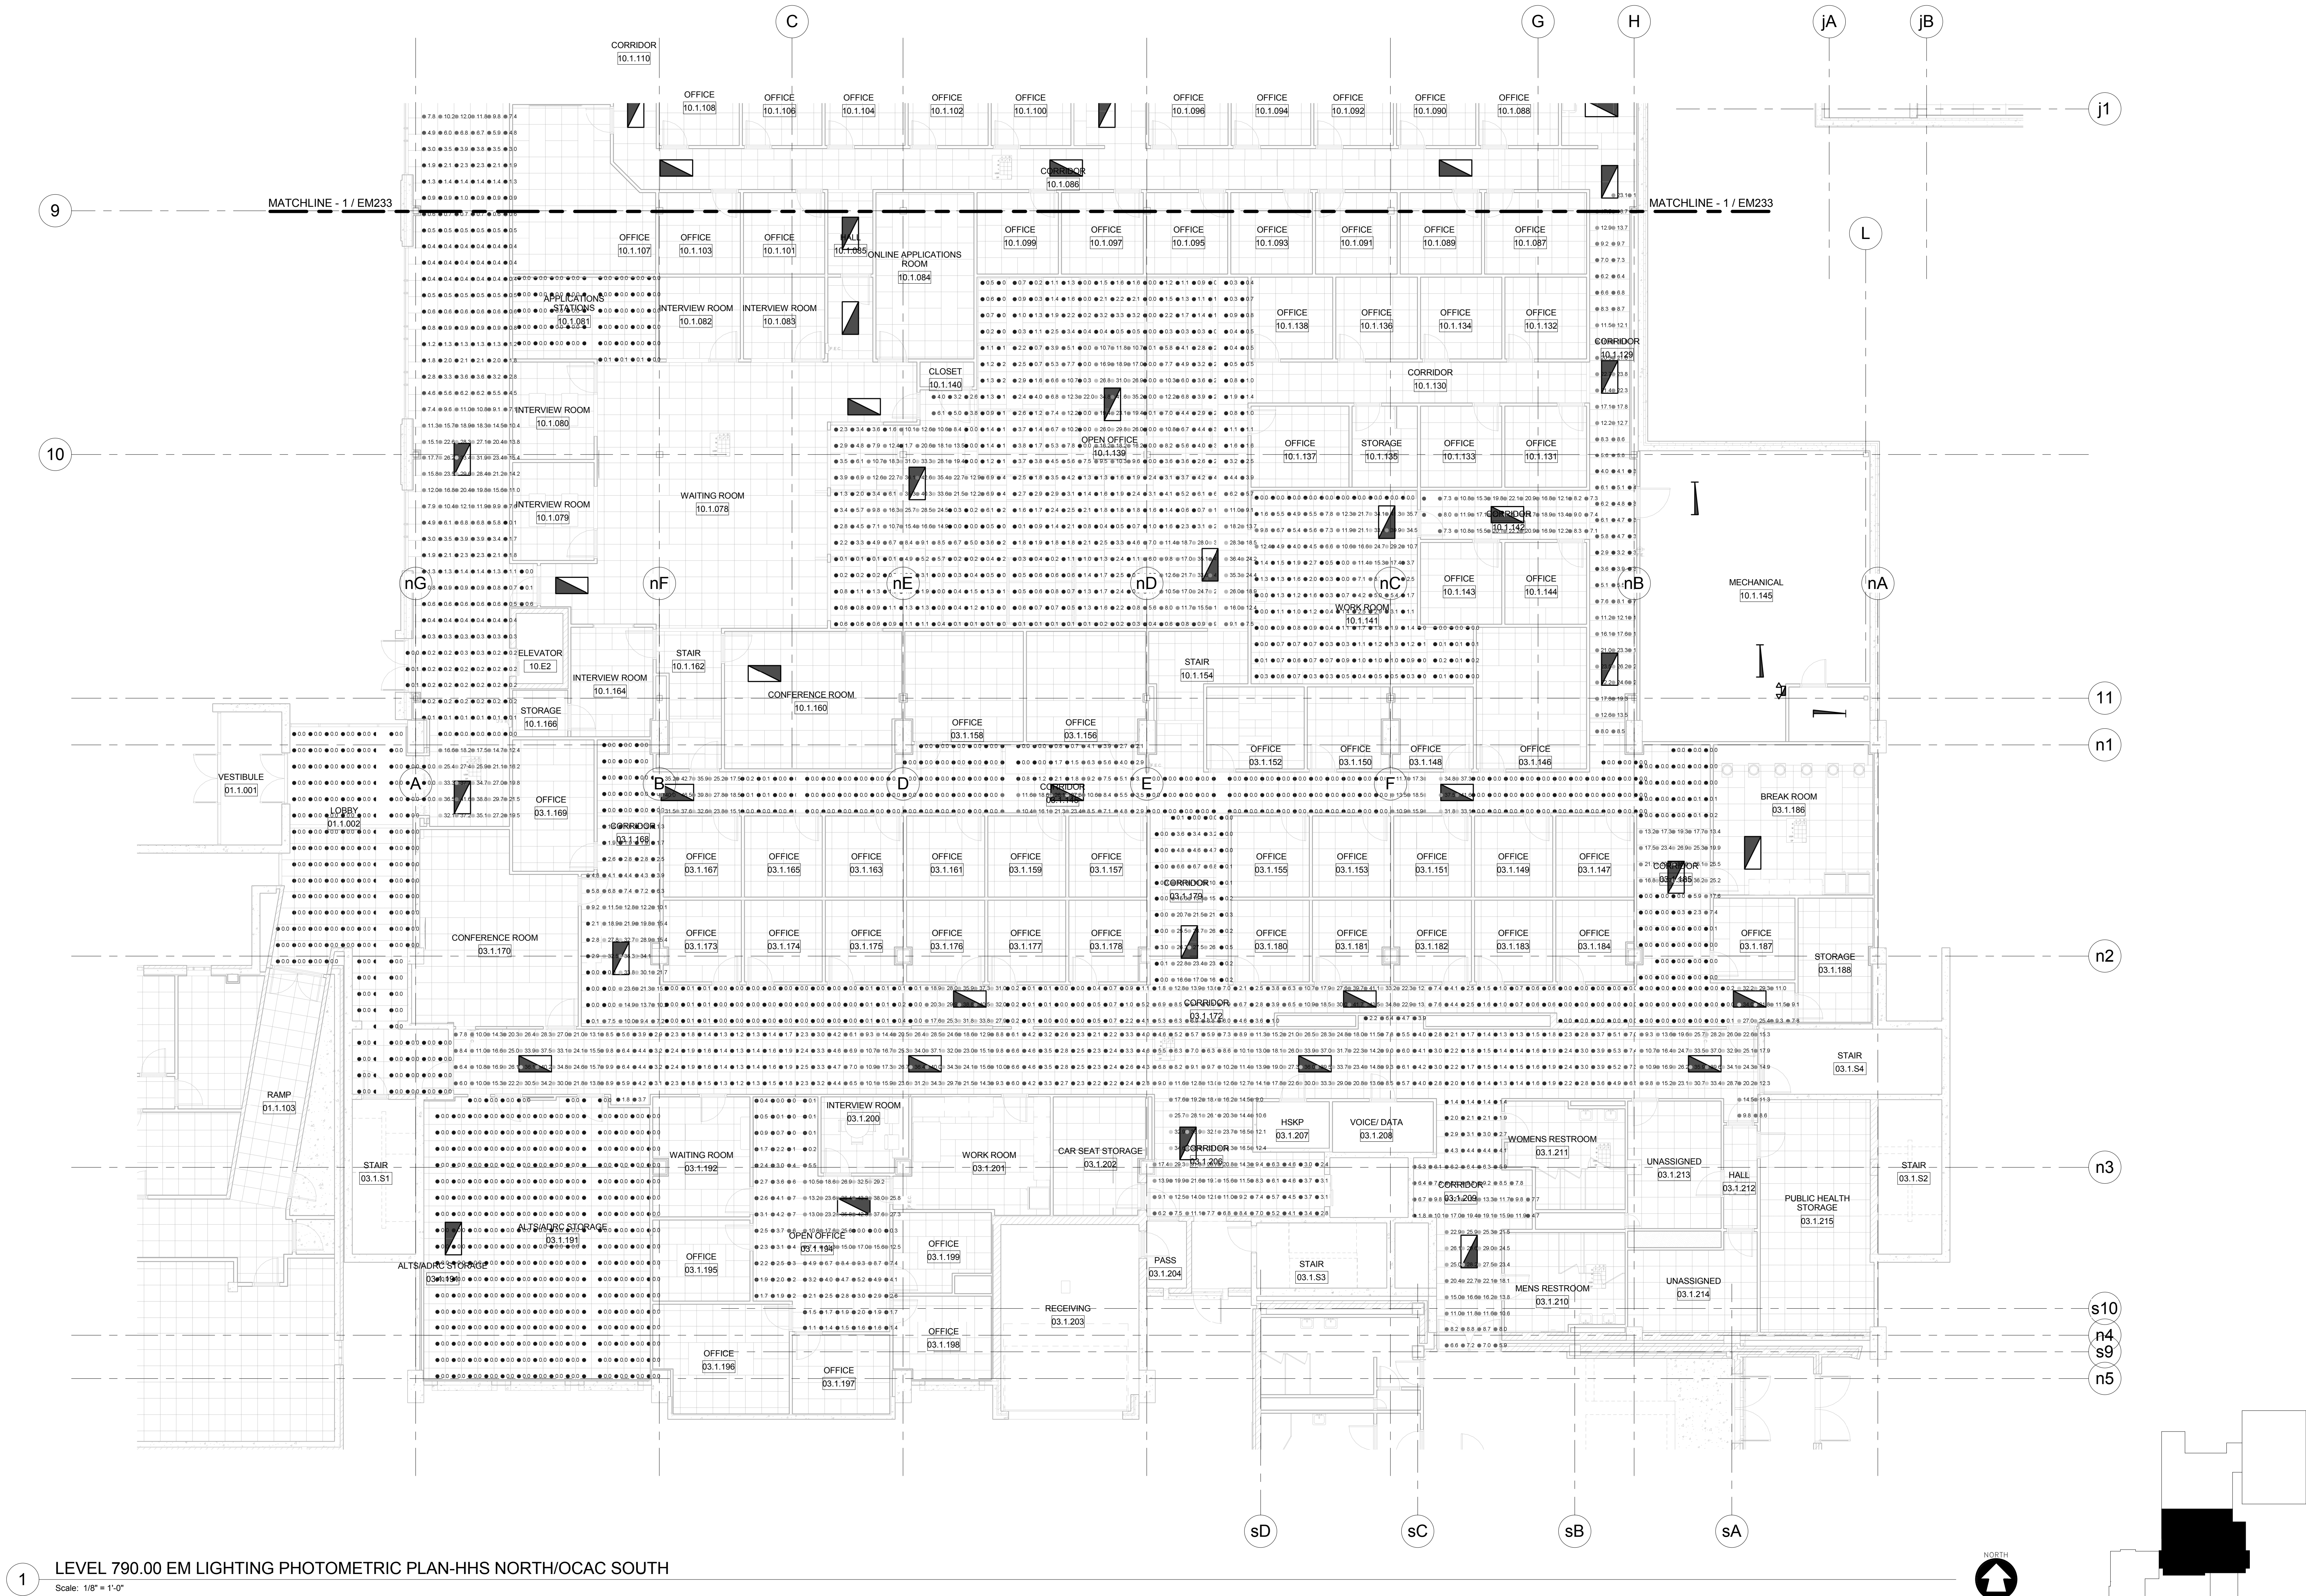


1 LEVEL 790.00 EM LIGHTING PHOTOMETRIC PLAN-HHS NORTH/OCAC SOUTH
Scale: 1/8" = 1'-0"


McMahon provides this drawing as an instrument of service. All rights are reserved. The client agrees to indemnify and hold McMahon harmless from all claims, damages, costs and expenses, including reasonable attorneys' fees, arising from the use of this drawing, whether or not such claims, damages, costs and expenses are caused in whole or in part by the negligence of McMahon.

DATE	REVISION

ALTERATION / ADDITION
OUTAGAMIE COUNTY ADMINISTRATION CENTER
S. WALNUT & W. 8TH, APPLETON WI 54911
LEVEL 790.00 EM LIGHTING PHOTOMETRIC PLAN-HHS NORTH/OCAC SOUTH

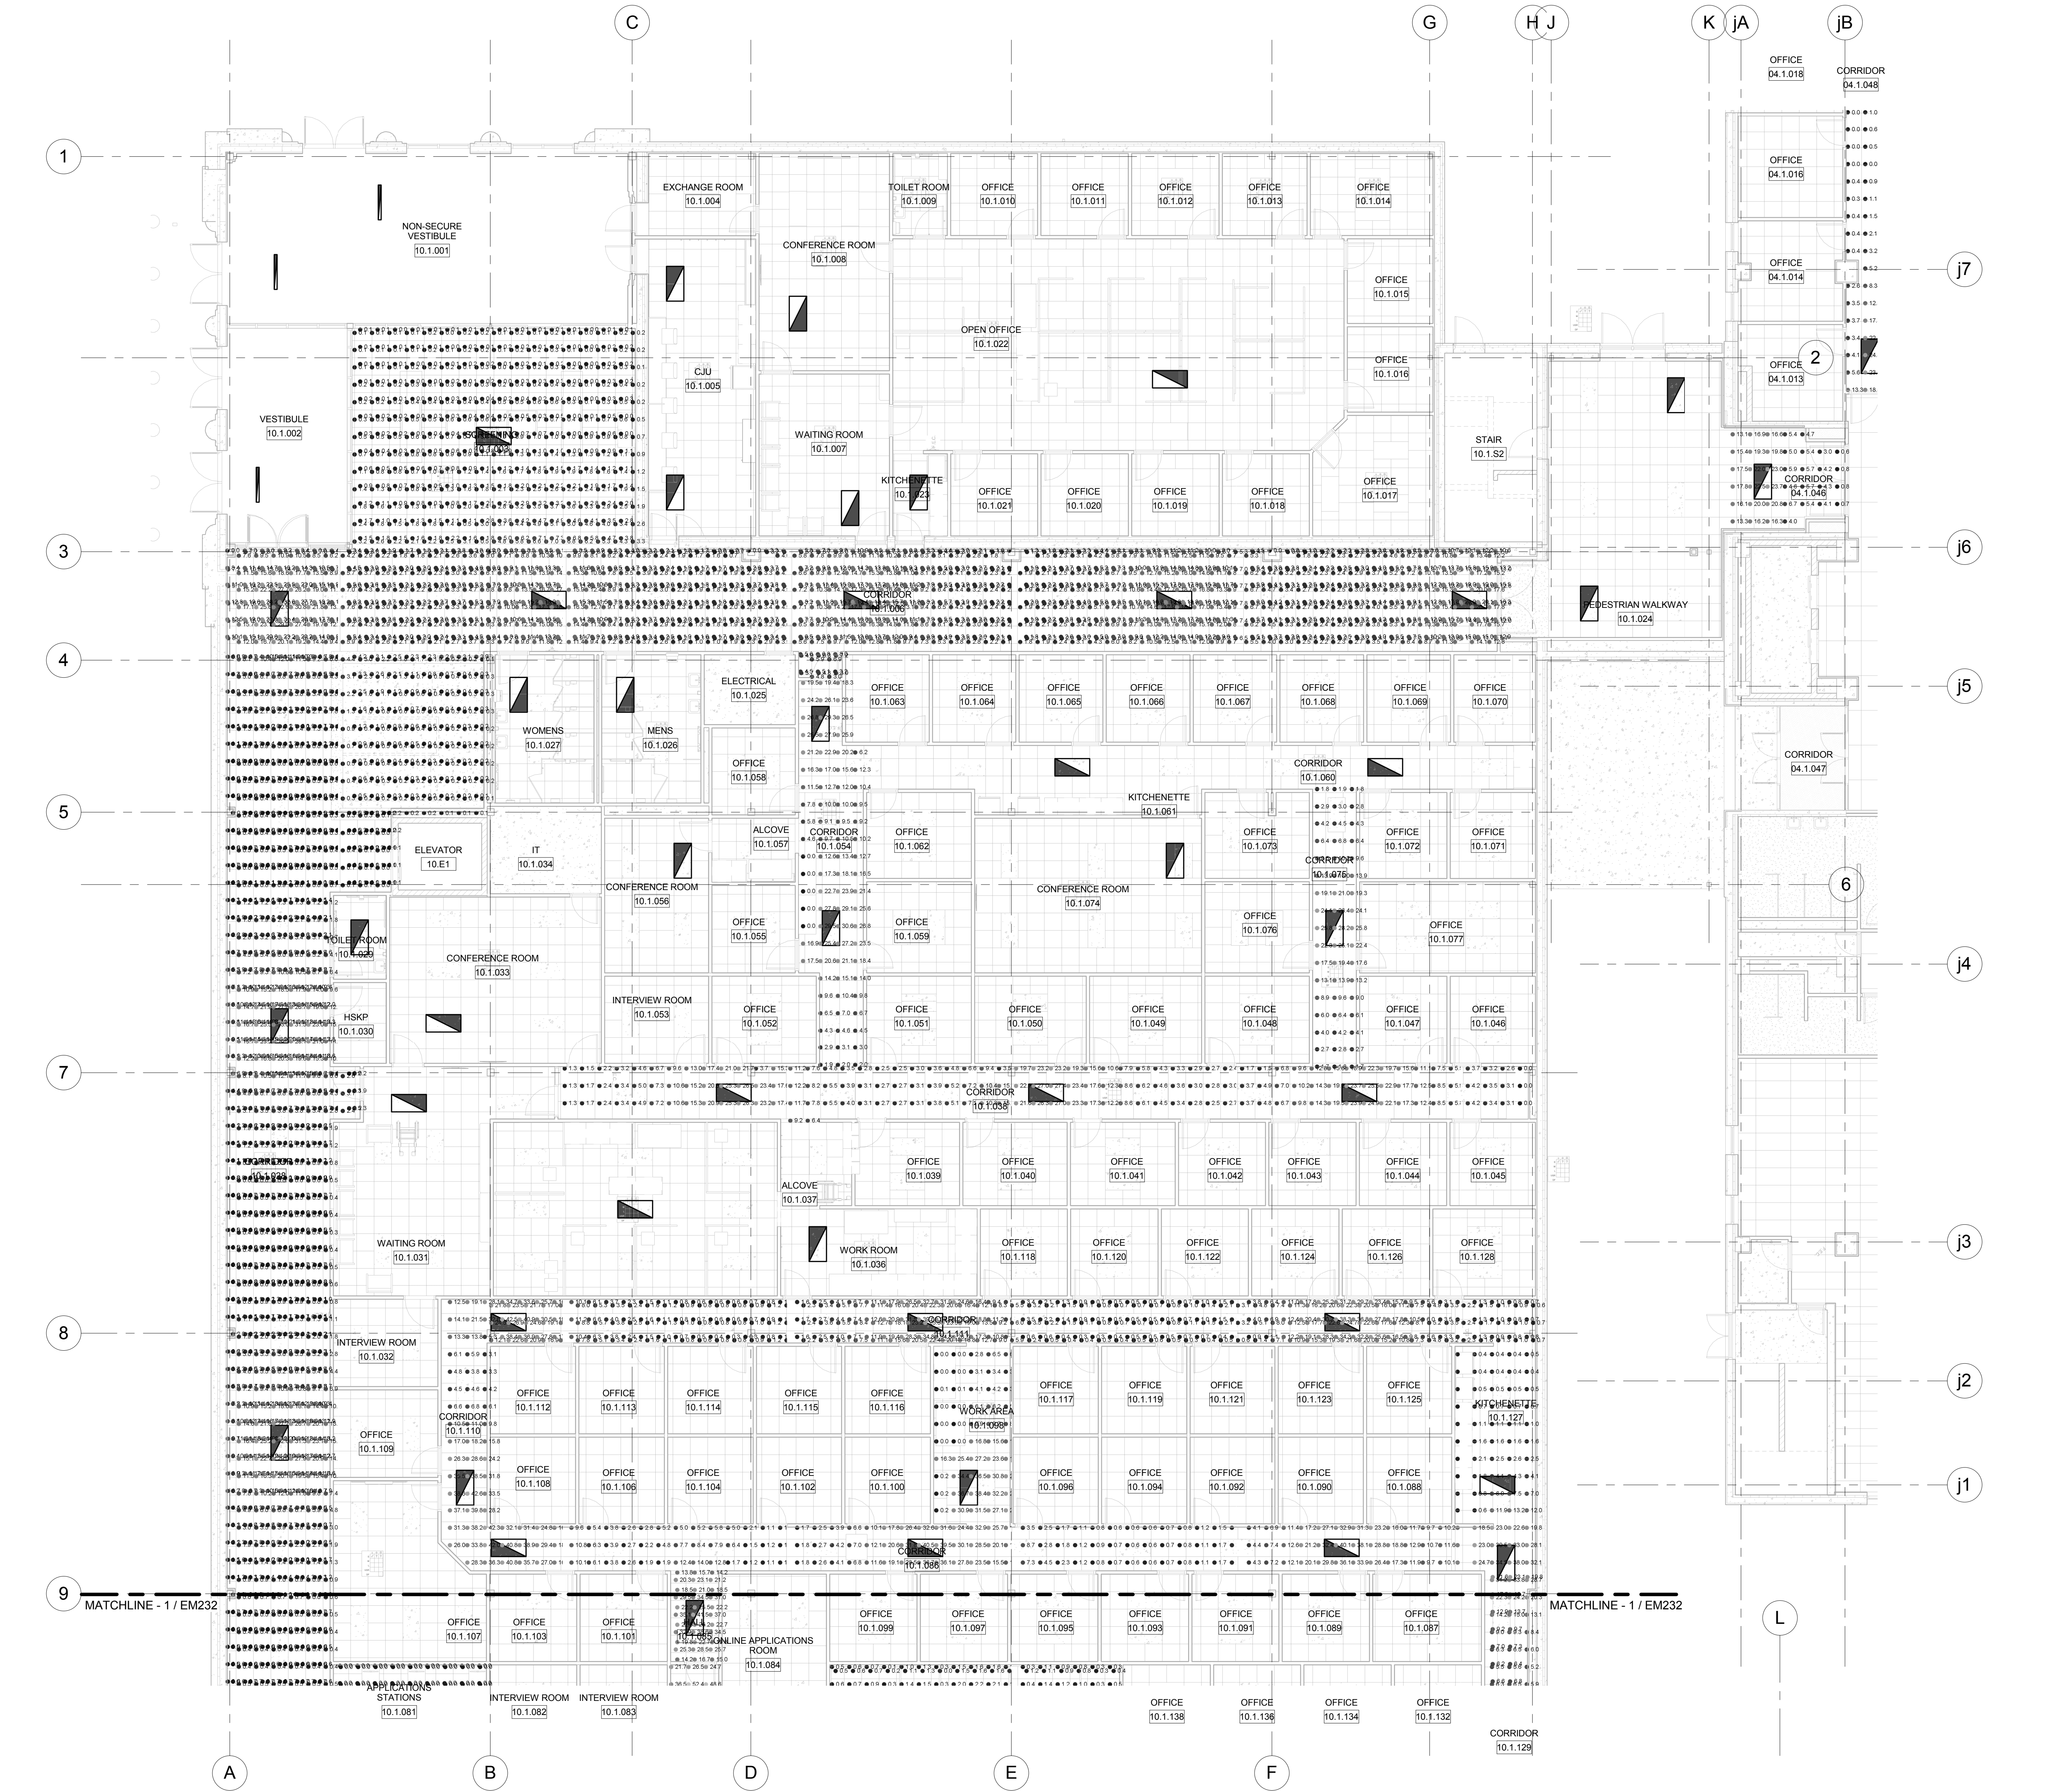

1 LEVEL 790.00 EM LIGHTING PHOTOMETRIC PLAN-OCAC NORTH
Scale: 1/8" = 1'-0"

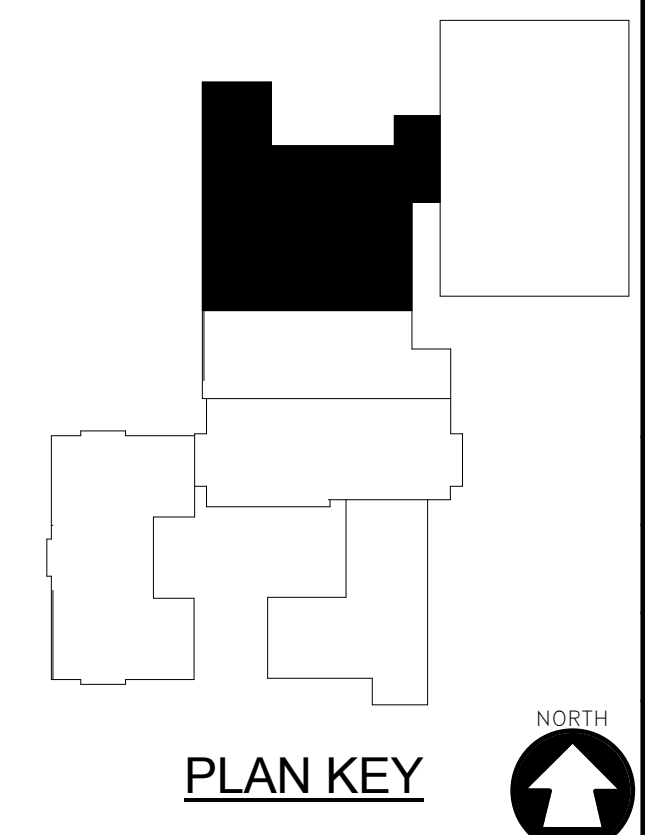

McMAHON
ENGINEERS ARCHITECTS
Maine P.O. BOX 1025 NEWBATH, VT 05457-1025
Tel: (820) 751-4200 Fax: (820) 751-4284
www.mhngroup.com

DESIGNED
CEH

DRAWN
MAL

PROJECT NO.
00002-61600160


DATE
MARCH 3, 2017


SHEET NO.
EM233

ALTERATION / ADDITION
OUTAGAMIE COUNTY ADMINISTRATION CENTER
S. WALNUT & W. 8TH, APPLETON WI 54911
LEVEL 790.00 EM LIGHTING PHOTOMETRIC PLAN-OCAC NORTH

REVISION

NO.	DATE	DESCRIPTION

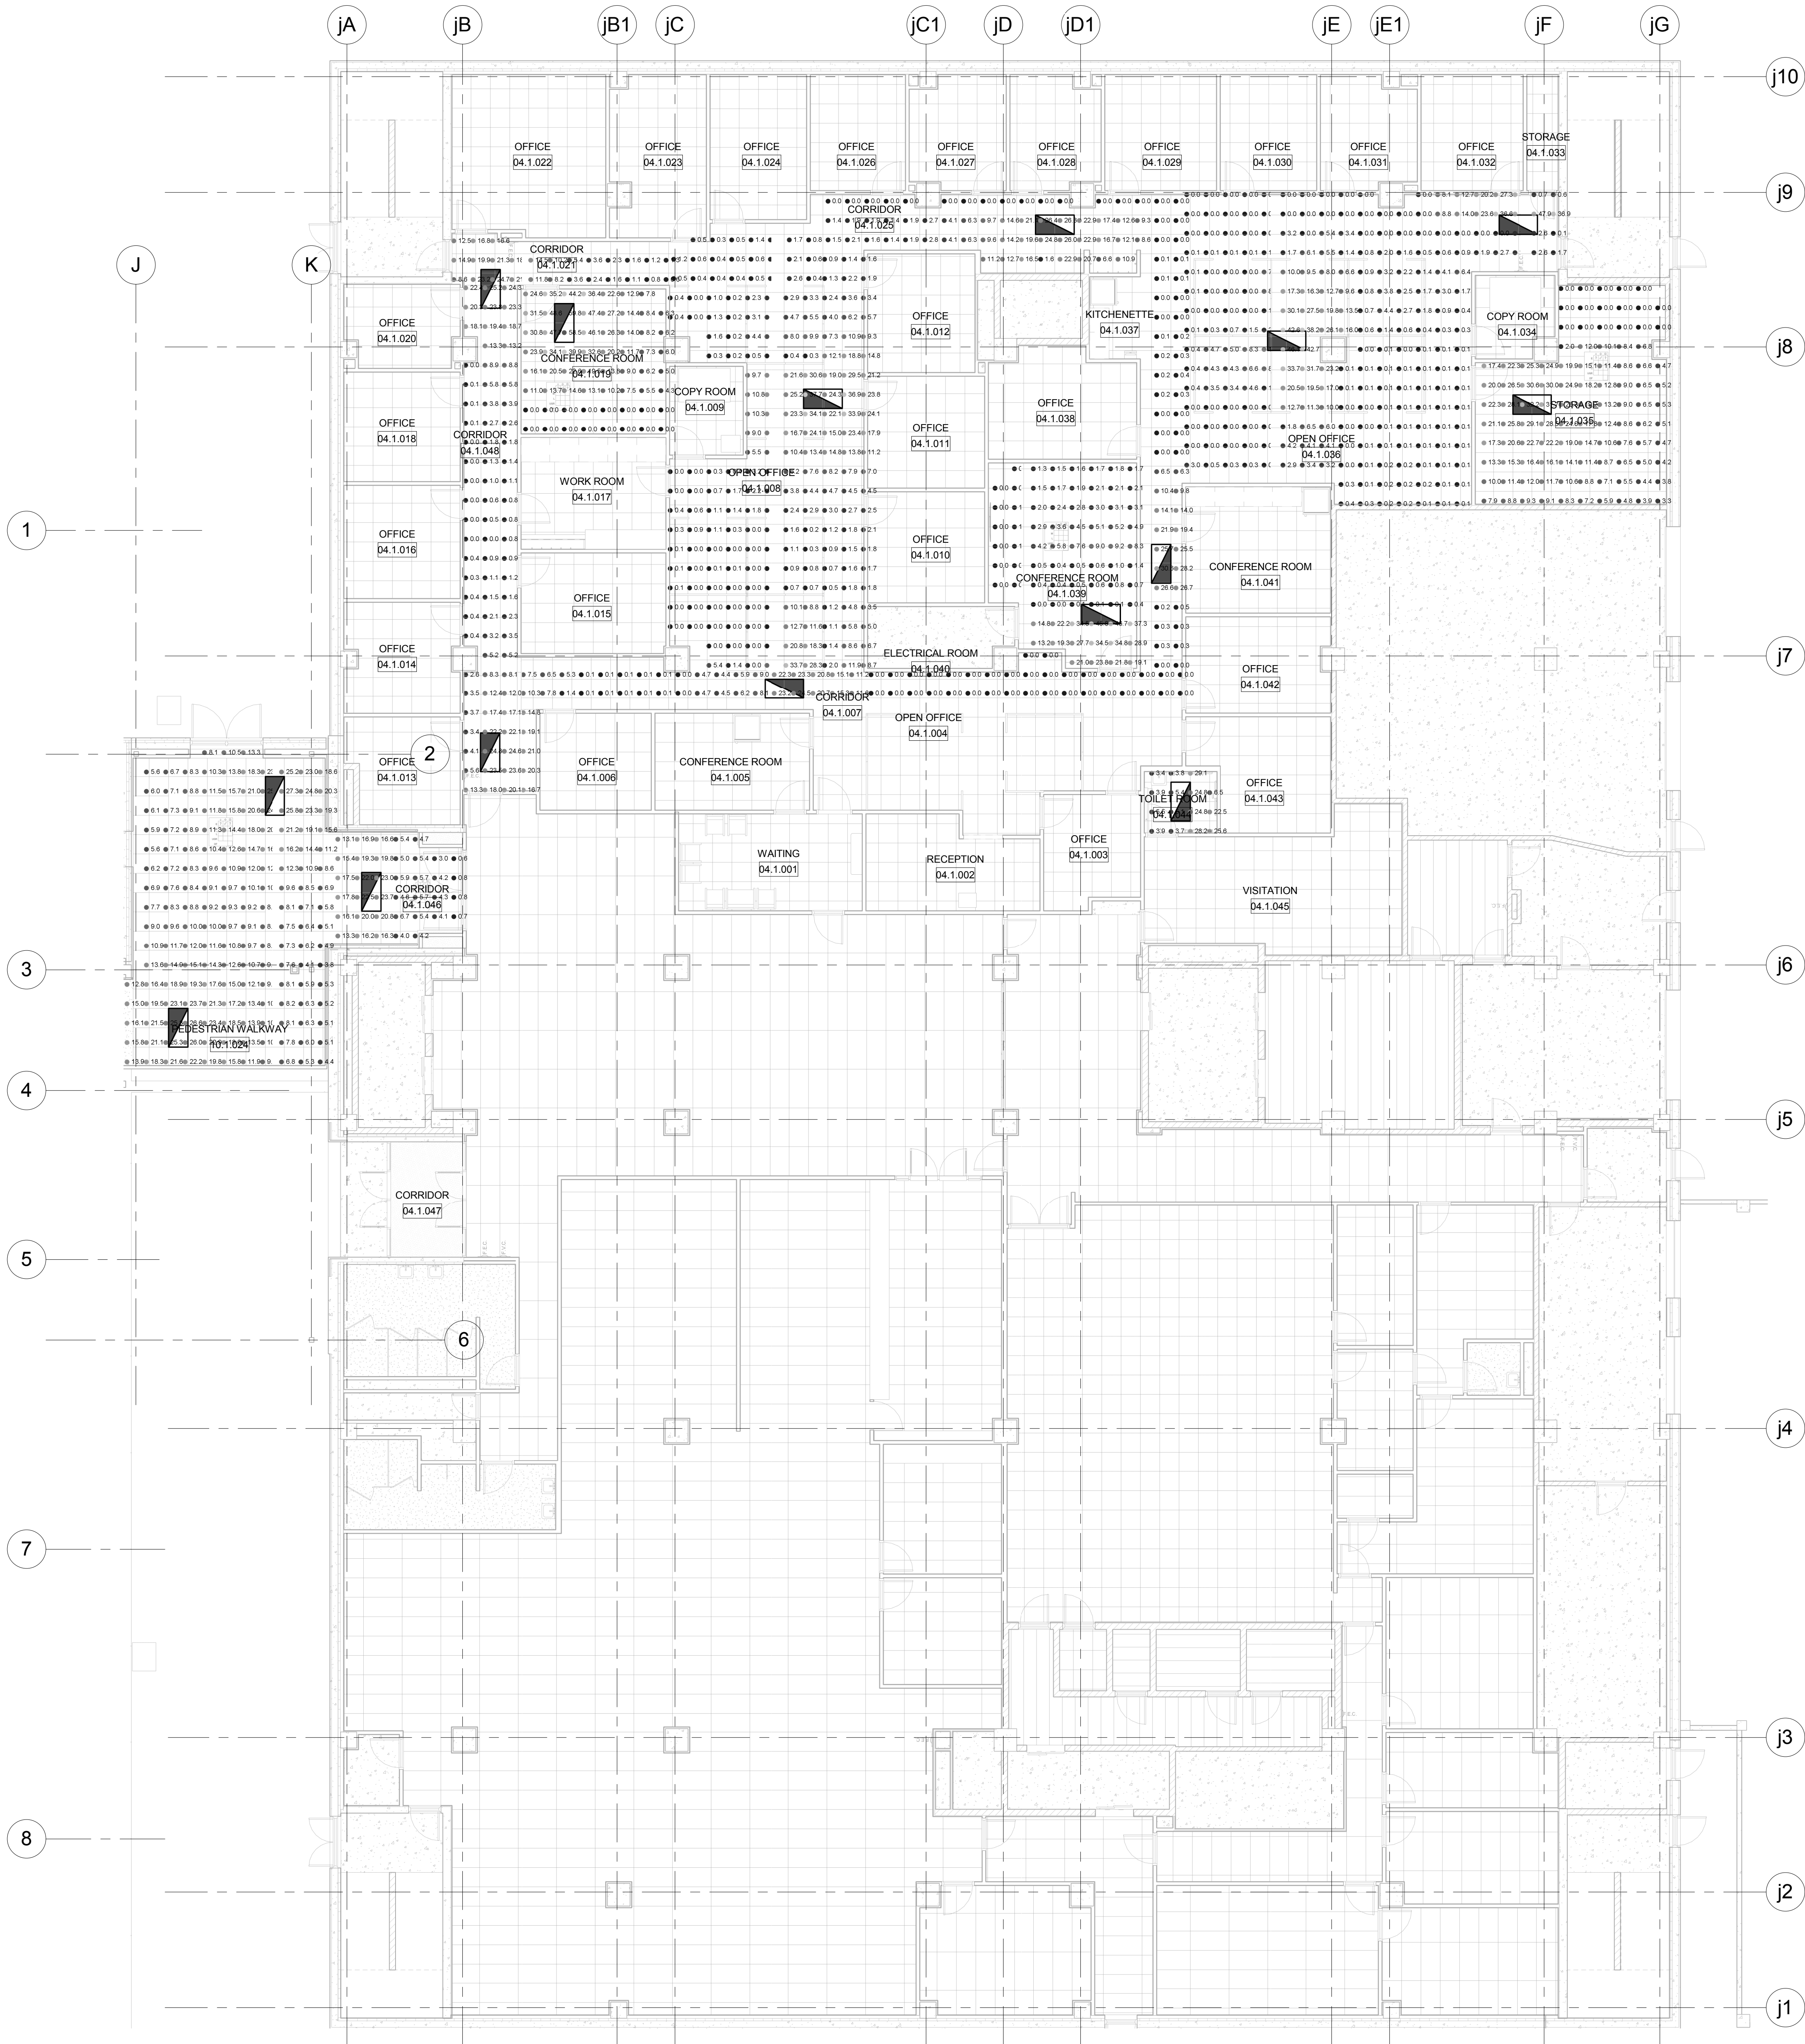

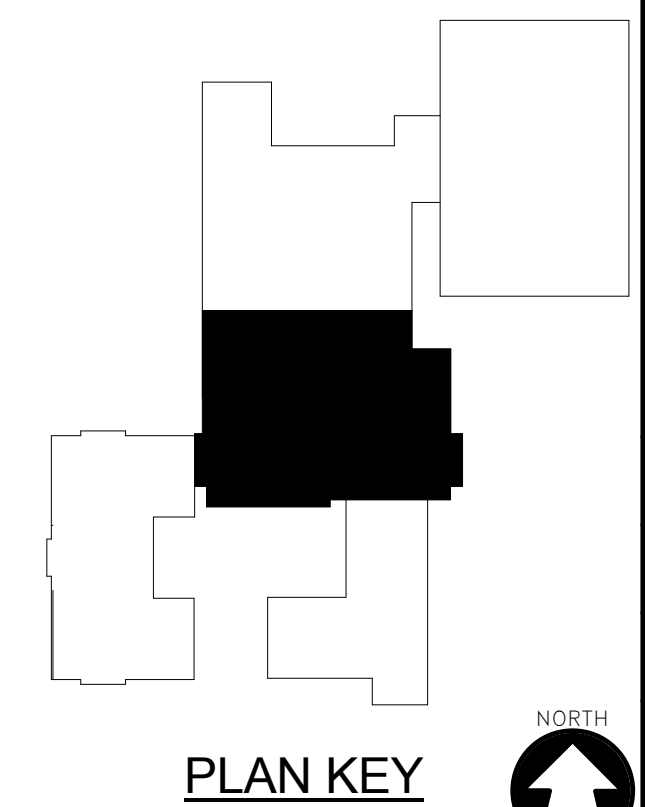

1 LEVEL 805.00 EM LIGHTING PHOTOMETRIC PLAN-HHS NORTH/OCAC SOUTH
Scale: 1/8" = 1'-0"

PLAN KEY

NORTH

McMAHON
ENGINEERS ARCHITECTS
1445 McMAHON DRIVE NEEAH, WI 54956
Mailing: P.O. BOX 1025 NEEAH, WI 54957-1025
Tel: (920) 751-4200 Fax: (920) 751-4284
www.mcmgrp.com

McMahon provides this drawing and data, regardless of form, as instruments of service. All rights including copyrights are retained by McMahon. The client and/or recipient agrees to the fullest extent permitted by law to indemnify and hold McMahon harmless for any use of or changes made to the original drawing or data without prior written consent by McMahon.


[illegible]

ALTERATION / ADDITION


OUTAGAMIE COUNTY ADMINISTRATION CENTER
S. WALNUT & W. 8TH, APPLETON WI 54911

LEVEL 805.00 EM LIGHTING PHOTOMETRIC PLAN-HHS NORTH/OACAC SOUTH

DESIGNED CEH	DRAWN MAL
PROJECT NO. O0002-61600160	
DATE MARCH 3, 2017	
SHEET NO. FM275	

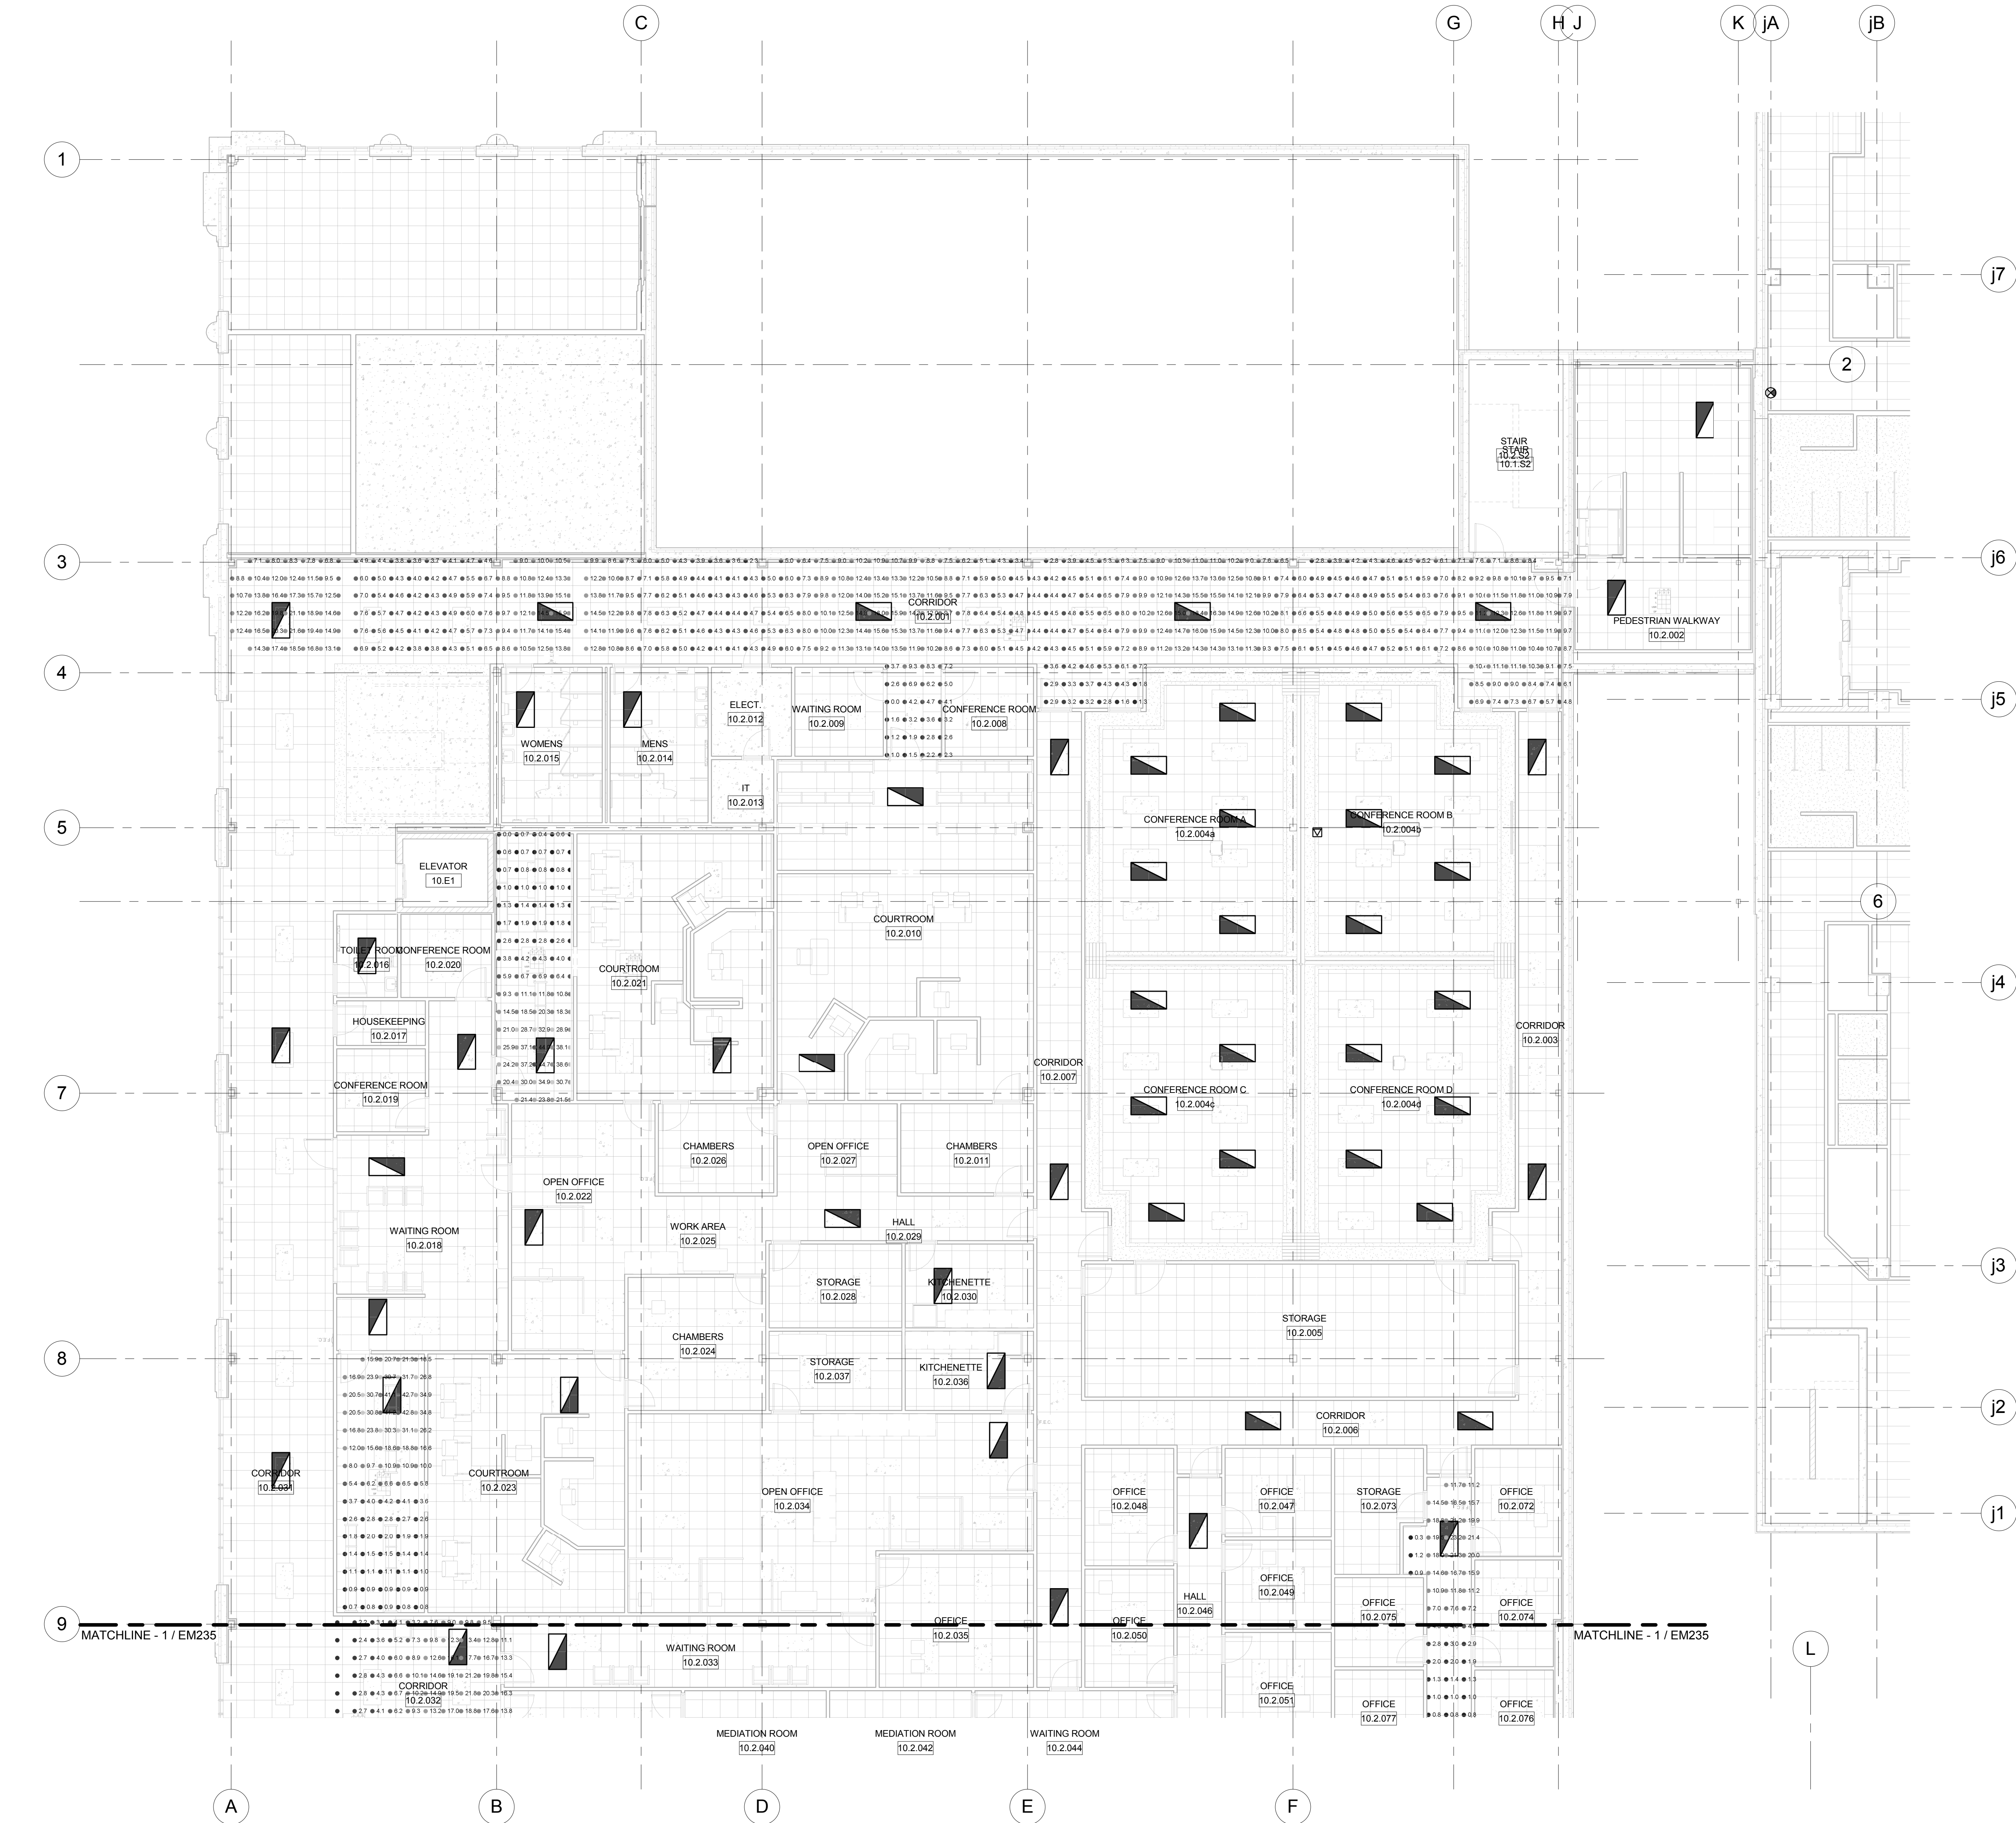

1 LEVEL 805.00 EM LIGHTING PHOTOMETRIC PLAN-OCAC NORTH
Scale: 1/8" = 1'-0"

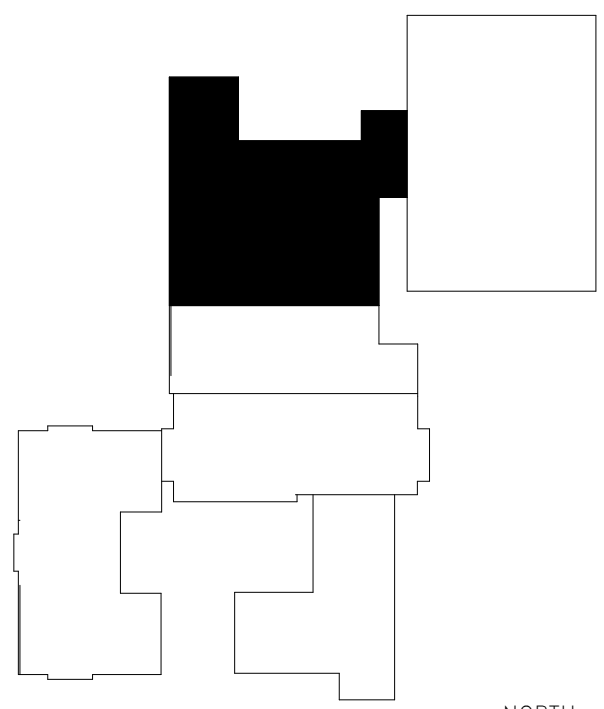

McMahon provides this drawing as instruments of service. All rights are reserved by McMahon. The client agrees to indemnify and hold McMahon harmless from all claims, damages, costs and expenses, including reasonable attorneys' fees, arising from the use of this drawing, whether or not such claims, damages, costs and expenses are caused in whole or in part by the negligence of McMahon.

NO.	DATE	REVISION

NO.	DATE	REVISION

ALTERATION / ADDITION
OUTAGAMIE COUNTY ADMINISTRATION CENTER
S. WALNUT & W. 8TH, APPLETON WI 54911
LEVEL 805.00 EM LIGHTING PHOTOMETRIC PLAN-OCAC NORTH

DESIGNED CEH	DRAWN MAL
PROJECT NO. 00002-61600160	
DATE MARCH 3, 2017	
SHEET NO. EM236	



1 LEVEL 805.00 EM LIGHTING PHOTOMETRIC PLAN-JUSTICE CENTER
Scale: 1/8" = 1'-0"


McMahon provides this drawing and data, regardless of form, as instruments of service. All rights including copyrights are retained by McMahon. The client and/or recipient agrees to the fullest extent permitted by law to indemnify and hold McMahon harmless for any reuse of or changes made to the original drawing or data without prior written consent by McMahon.

[illegible]


4


3

EM237

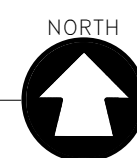


1 LEVEL 820.00 EM LIGHTING PHOTOMETRIC PLAN-HHS NORTH/OCAC SOUTH
Scale: 1/8" = 1'-0"

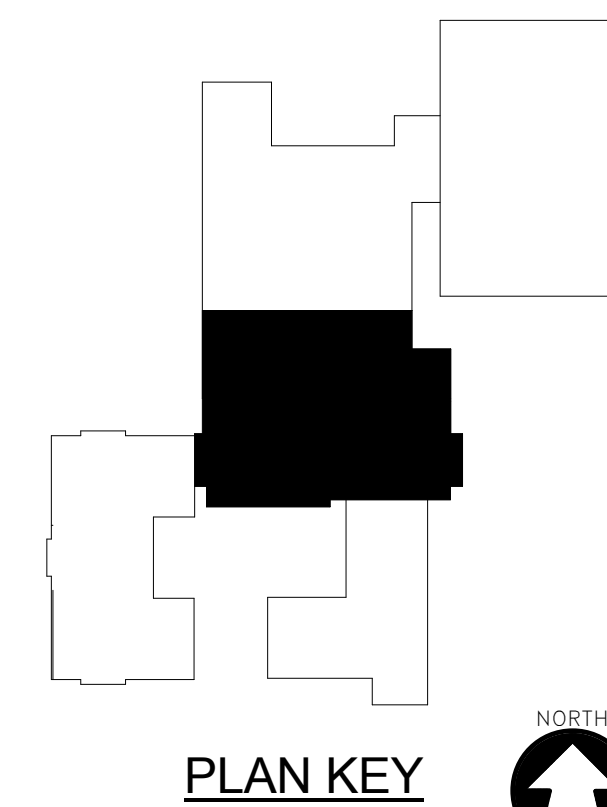

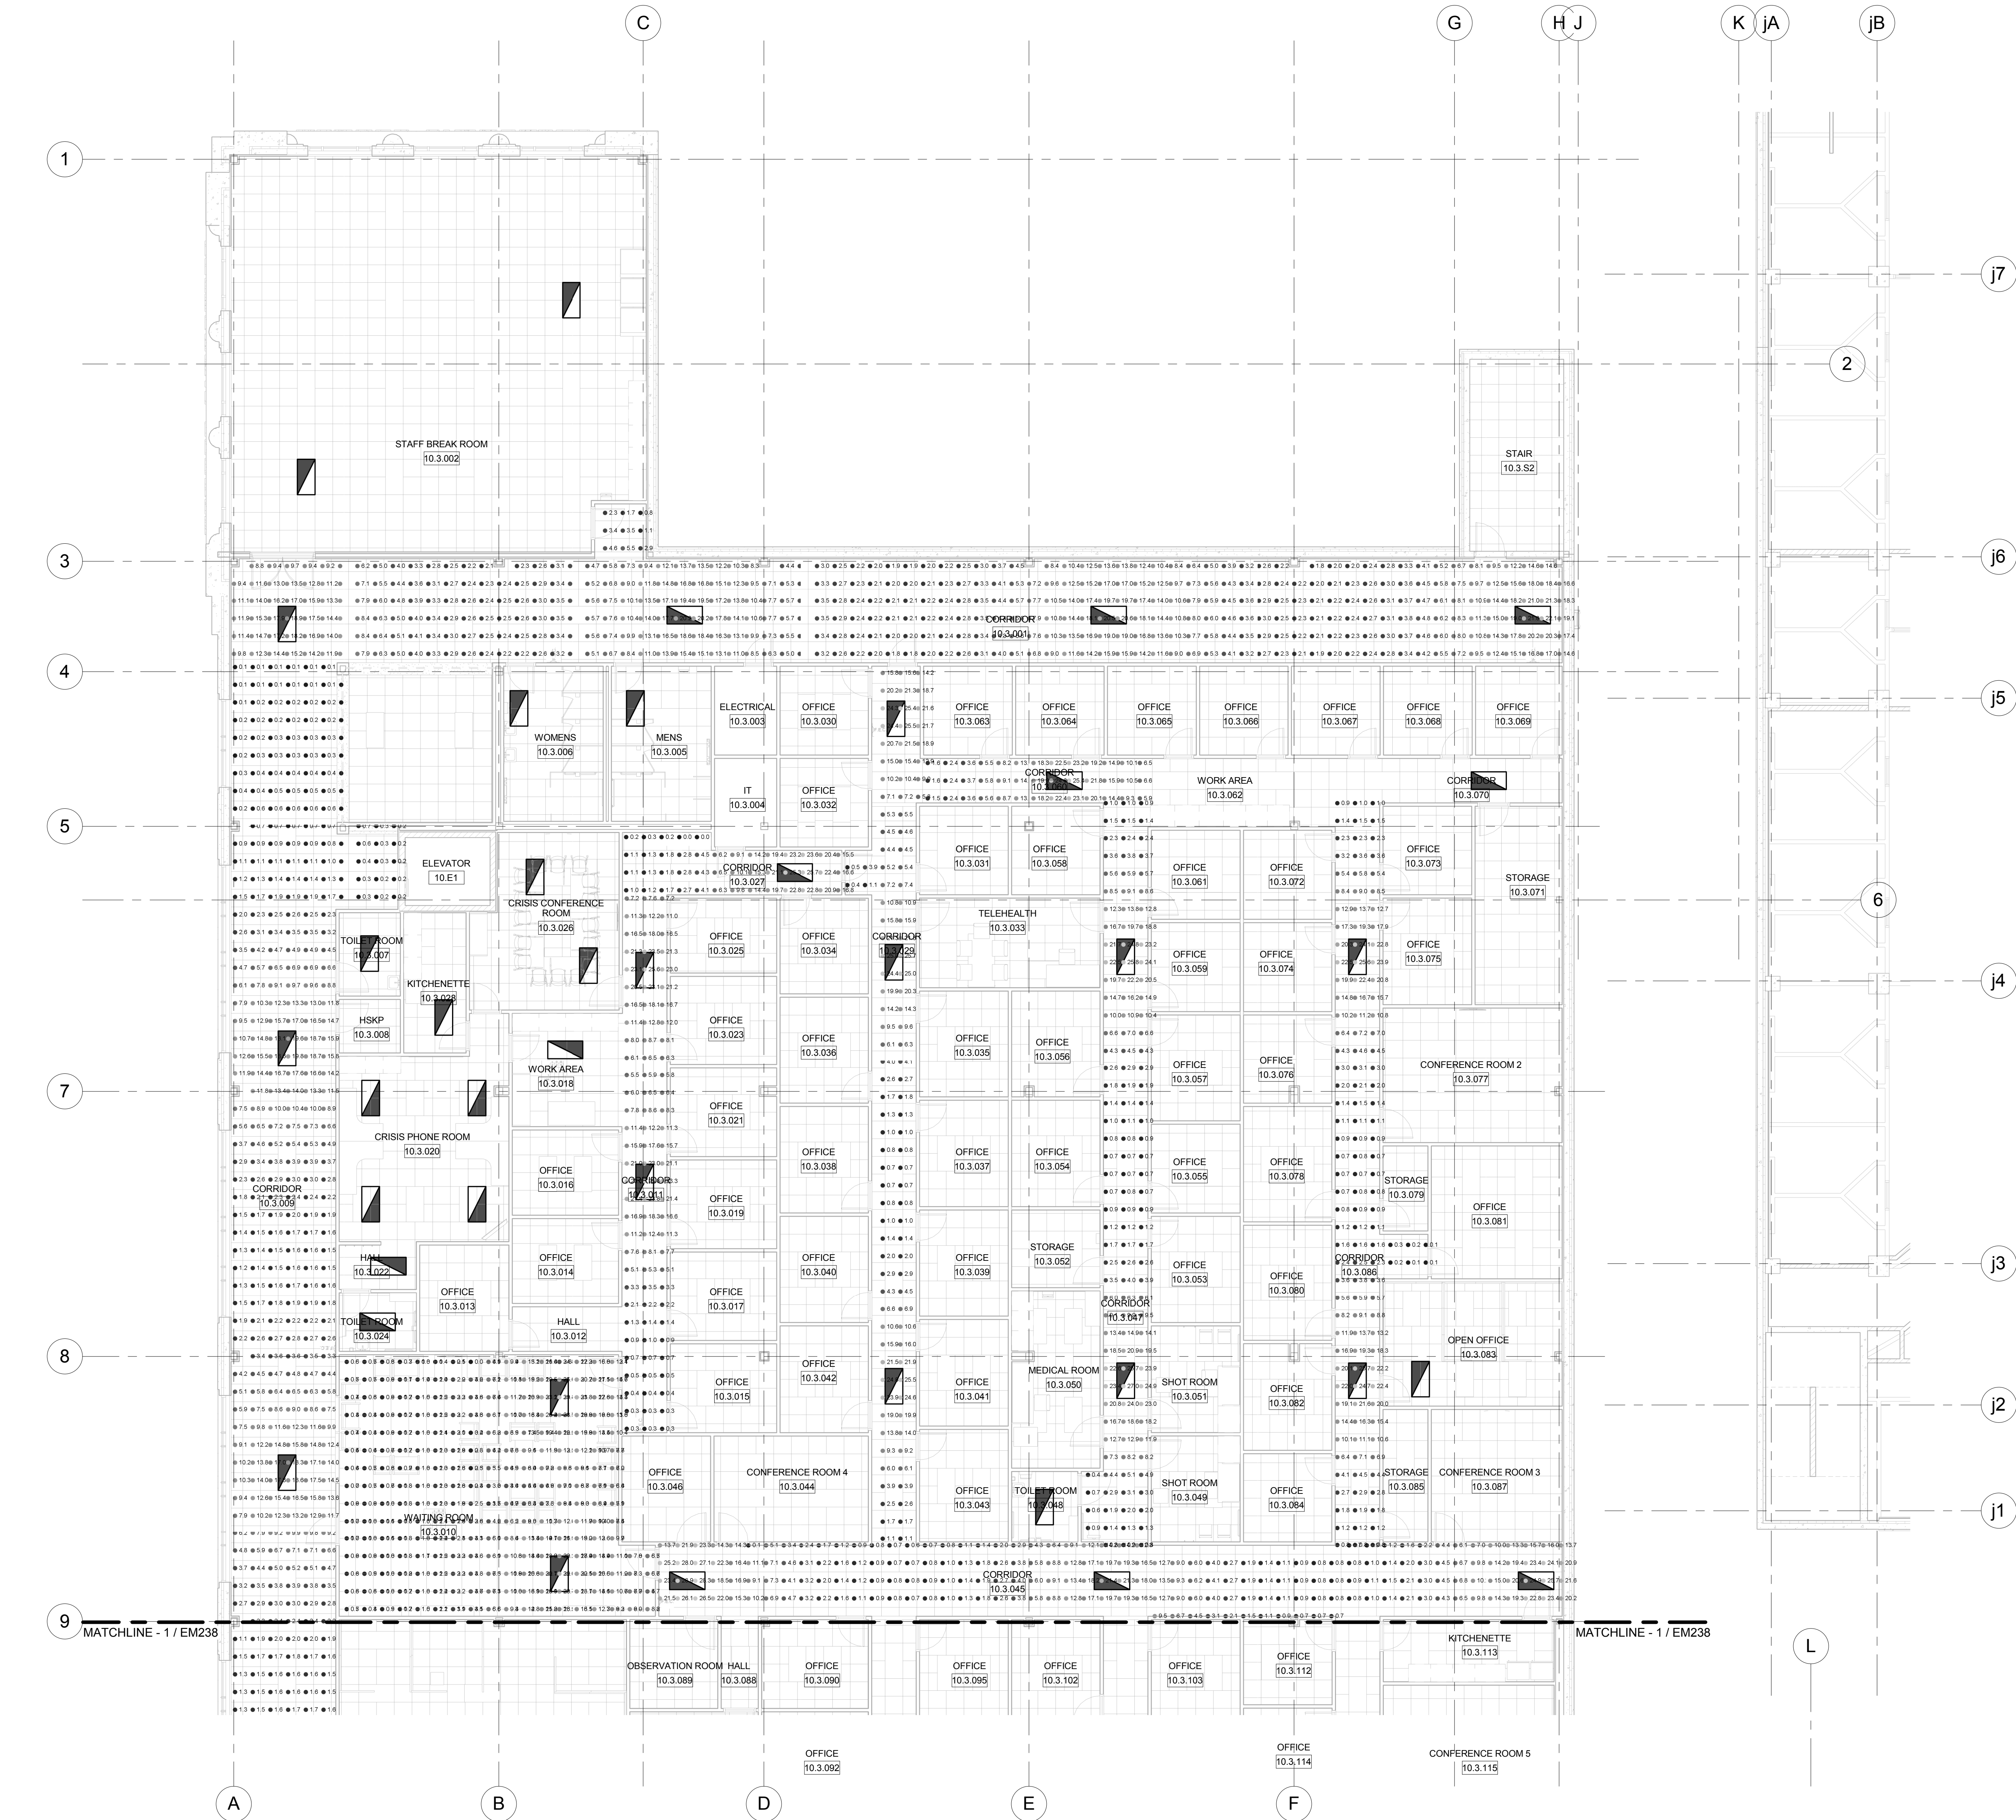

1 LEVEL 820.00 EM LIGHTING PHOTOMETRIC PLAN-OCAC NORTH
Scale: 1/8" = 1'-0"

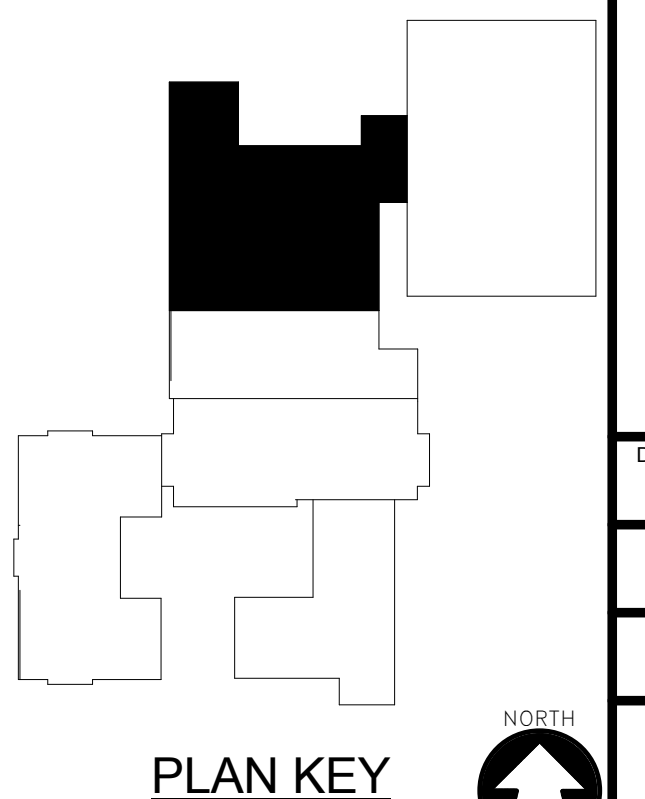

McMahon provides this drawing as a service to the client. It is not to be used for any other purpose without the written consent of McMahon. The client is responsible for obtaining all necessary permits and approvals for the project. McMahon is not responsible for any errors or omissions in this drawing.

NO.	DATE	REVISION

NO.	DATE	REVISION

NO.	DATE	REVISION

NO.	DATE	REVISION

NO.	DATE	REVISION

NO.	DATE	REVISION

NO.	DATE	REVISION



COMcheck Software Version 4.0.5.4
Interior Lighting Compliance
Certificate

Section 1: Project Information

Energy Code: 2009 IECC
Project Title:
Project Type: New Construction
Construction Site: Owner/Agent: Designer/Contractor:

Section 2: Interior Lighting and Power Calculation

A Area Category	B Floor Area (ft2)	C Allowed Watts / ft2	D Allowed Watts (B x C)
780 HHS NORTH (Office)	1465	1	1465
780 JUSTICE CENTER (Office)	5581	1	5581
790 CAB (Office)	3847	1	3847
790 OCAC (Office)	43940	1	43940
790 JUSTICE CENTER (Office)	9142	1	9142
805 OCAC (Office)	41159	1	41159
805 JUSTICE CENTER (Office)	2080	1	2080
820 OCAC (Office)	40348	1	40348
820 CAB (Office)	206	1	206
Total Allowed Watts =			147768

Section 3: Interior Lighting Fixture Schedule

A Fixture ID : Description / Lamp / Wattage Per Lamp / Ballast	B Lamps/ Fixture	C # of Fixtures	D Fixture Watt.	E (C X D)
780 HHS NORTH (Office 1465 sq.ft.)				
LED 1: AA: LED Panel 60W:	1	27	52.2	1409.4
LED 6: WA: LED Panel 33W:	1	1	32	32
780 JUSTICE CENTER (Office 5581 sq.ft.)				
LED 7: AA: LED Panel 60W:	1	10	52.2	522
LED 8: AB: LED Panel 60W:	1	16	52.2	835.2
LED 9: AC: LED Panel 60W:	1	16	52.2	835.2
LED 7 copy 1: AAE: LED Panel 60W:	1	6	52.2	313.2
LED 10: ABE: LED Panel 60W:	1	4	52.2	208.8
LED 11: ACE: LED Panel 60W:	1	13	52.2	678.6
LED 7 copy 2: EX: LED Panel 60W:	1	17	52.2	887.4
790 CAB (Office 3847 sq.ft.)				
LED 13 copy 1: AA: 2x4: LED Panel 60W:	1	21	52.2	1096.2
LED 16 copy 1: ABE: 2x4: LED Panel 60W:	1	8	52.2	417.6
LED 13 copy 2: EX: 2x4: LED Panel 60W:	1	30	52.2	1566
LED 13 copy 3: EXE: 2x4: LED Panel 60W:	1	5	52.2	261
790 OCAC (Office 43940 sq.ft.)				
LED 13: AA: LED Panel 60W:	1	320	52.2	16704
LED 14: AB: LED Panel 60W:	1	164	52.2	8560.8
LED 15: AC: LED Panel 60W:	1	47	52.2	2453.4
LED 16: AAE: LED Panel 60W:	1	4	52.2	208.8
LED 17: ABE: LED Panel 60W:	1	62	52.2	3236.4
LED 18: ACE: LED Panel 60W:	1	8	52.2	417.6

Project Title: Data filename: C:\Users\Aholloway.FAITH1\Desktop\Revit Projects\OCAC\170227_OCAC.cck Report date: 02/27/17 Page 1 of 3

LED 19: KA: LED Panel 33W:	1	7	32	224
LED 19 copy 1: KAE: LED Panel 33W:	1	2	32	64
LED 20 copy 1: AD: LED Panel 33W:	1	12	34	408
790 JUSTICE CENTER (Office 9142 sq.ft.)				
LED 21: AA: LED Panel 60W:	1	87	52.2	4541.4
LED 21 copy 1: AB: LED Panel 60W:	1	14	52.2	730.8
LED 21 copy 2: AC: LED Panel 60W:	1	22	52.2	1148.4
LED 21 copy 3: ABE: LED Panel 60W:	1	10	52.2	522
LED 21 copy 4: ACE: LED Panel 60W:	1	3	52.2	156.6
805 OCAC (Office 41159 sq.ft.)				
LED 13 copy 1: AA: LED Panel 60W:	1	210	52.2	10962
LED 14 copy 1: AB: LED Panel 60W:	1	137	52.2	7151.4
LED 15 copy 1: AC: LED Panel 60W:	1	86	52.2	4489.2
LED 16 copy 1: AAE: LED Panel 60W:	1	3	52.2	156.6
LED 17 copy 1: ABE: LED Panel 60W:	1	52	52.2	2714.4
LED 18 copy 1: ACE: LED Panel 60W:	1	32	52.2	1670.4
LED 19 copy 1: KA: LED Panel 33W:	1	8	32	256
LED 19 copy 2: KAE: LED Panel 33W:	1	1	32	32
LED 20 copy 1: WA: LED Panel 33W:	1	5	32	160
805 JUSTICE CENTER (Office 2080 sq.ft.)				
LED 15 copy 2: AC: LED Panel 60W:	1	21	52.2	1096.2
LED 17 copy 2: ABE: LED Panel 60W:	1	8	52.2	417.6
820 OCAC (Office 40348 sq.ft.)				
LED 13 copy 2: AA: LED Panel 60W:	1	359	52.2	18739.8
LED 14 copy 2: AB: LED Panel 60W:	1	125	52.2	6525
LED 15 copy 2: AC: LED Panel 60W:	1	37	52.2	1931.4
LED 16 copy 2: AAE: LED Panel 60W:	1	3	52.2	156.6
LED 17 copy 2: ABE: LED Panel 60W:	1	57	52.2	2975.4
LED 18 copy 2: ACE: LED Panel 60W:	1	2	52.2	104.4
LED 19 copy 2: KA: LED Panel 33W:	1	8	32	256
LED 19 copy 3: KAE: LED Panel 33W:	1	1	32	32
LED 20 copy 2: WA: LED Panel 33W:	1	2	32	64
820 CAB (Office 206 sq.ft.)				
LED 13 copy 3: AA: LED Panel 60W:	1	5	52.2	261
LED 13 copy 4: D1: RECESSED CAN: LED Panel 60W:	1	5	35	175
Total Proposed Watts =				108765

Section 4: Requirements Checklist

Interior Lighting PASSES: Design 26% better than code.

- Lighting Wattage:
- ☐ 1. Total proposed watts must be less than or equal to total allowed watts.
- | Allowed Watts | Proposed Watts | Complies |
|---------------|----------------|----------|
| 147768 | 108765 | YES |
- Controls, Switching, and Wiring:
- ☐ 2. Daylight zones under skylights more than 15 feet from the perimeter have lighting controls separate from daylight zones adjacent to vertical fenestration.
- ☐ 3. Daylight zones have individual lighting controls independent from that of the general area lighting.
- Exceptions:
- ☐ Contiguous daylight zones spanning no more than two orientations are allowed to be controlled by a single controlling device.
- ☐ Daylight spaces enclosed by walls or ceiling height partitions and containing two or fewer light fixtures are not required to have a separate switch for general area lighting.
- ☒ 4. Independent controls for each space (switch/occupancy sensor).
- Exceptions:
- ☐ Areas designated as security or emergency areas that must be continuously illuminated.
- ☐ Lighting in stairways or corridors that are elements of the means of egress.

Project Title: Data filename: C:\Users\Aholloway.FAITH1\Desktop\Revit Projects\OCAC\170227_OCAC.cck Report date: 02/27/17 Page 2 of 3


- ☐ 5. Master switch at entry to hotel/motel guest room.
- ☐ 6. Individual dwelling units separately metered.
- ☐ 7. Medical task lighting or arthistory display lighting claimed to be exempt from compliance has a control device independent of the control of the nonexempt lighting.
- ☒ 8. Each space required to have a manual control also allows for reducing the connected lighting load by at least 50 percent by either controlling all luminaires, dual switching of alternate rows of luminaires, alternate luminaires, or alternate lamps, switching the middle lamp luminaires independently of other lamps, or switching each luminaire or each lamp.
- Exceptions:
- ☐ Only one luminaire in space.
- ☐ An occupant-sensing device controls the area.
- ☐ The area is a corridor, storeroom, restroom, public lobby or sleeping unit.
- ☐ Areas that use less than 0.6 Watts/sq.ft.
- ☒ 9. Automatic lighting shutoff control in buildings larger than 5,000 sq.ft.
- Exceptions:
- ☐ Sleeping units, patient care areas; and spaces where automatic shutoff would endanger safety or security.
- ☐ 10. Photocell/astronomical time switch on exterior lights.
- Exceptions:
- ☐ Lighting intended for 24 hour use.
- ☐ 11. Tandem wired one-lamp and three-lamp ballasted luminaires (No single-lamp ballasts).
- Exceptions:
- ☐ Electronic high-frequency ballasts; Luminaires on emergency circuits or with no available pair.

Section 5: Compliance Statement

Compliance Statement: The proposed lighting design represented in this document is consistent with the building plans, specifications and other calculations submitted with this permit application. The proposed lighting system has been designed to meet the 2009 IECC requirements in COMcheck Version 4.0.5.4 and to comply with the mandatory requirements in the Requirements Checklist.

Emeka Okemuo - Elect Engr. Emeka Okemuo 2/27/2017
Name - Title Signature Date

Project Title: Data filename: C:\Users\Aholloway.FAITH1\Desktop\Revit Projects\OCAC\170227_OCAC.cck Report date: 02/27/17 Page 3 of 3

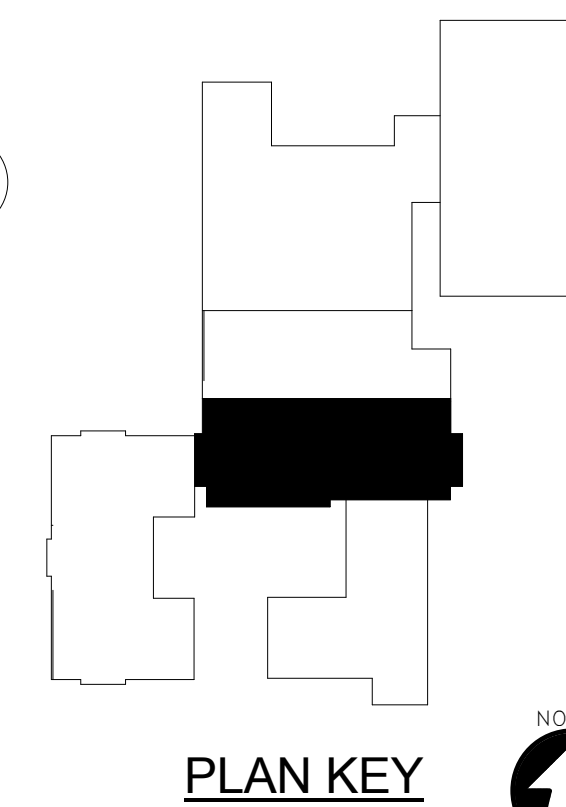

McMAHON
ENGINEERS ARCHITECTS
1445 McMAHON DRIVE NEEHAH, WI 54956
Mailing: P.O. BOX 1025 NEEHAH, WI 54957-1025
Tel: (920) 751-4200 Fax: (920) 751-4284
www.mcmahongr.com

[illegible]

ALTERATION / ADDITION
ROUTAGAMIE COUNTY ADMINISTRATION CENTER
S. WALNUT & W. 8TH, APPLETON WI 54911
LEVEL 780.00 POWER PLAN-HHS NORTH

DESIGNED RJW	DRAWN MAL
PROJECT NO. 00002-61600160	
DATE MARCH 3, 2017	
SHEET NO.	

EP229




1 LEVEL 79
Scale: 1/8" = 1'-0"



PLAN NOTES: #


1. PROVIDE NEW CIRCUITING TO EXISTING PANEL #90.
2. UPDATE EXISTING PANEL SCHEDULE WITH NEW CIRCUITS. SCHEDULE IS TO BE UPDATED MECHANICALLY.
3. EXTEND/ PROVIDE NEW CIRCUITS AS REQUIRED TO EXISTING PANELS
4. PROVIDED HARDWARE FURNITURE CONNECTION TO WORKSTATION FROM WALL LOCATION.

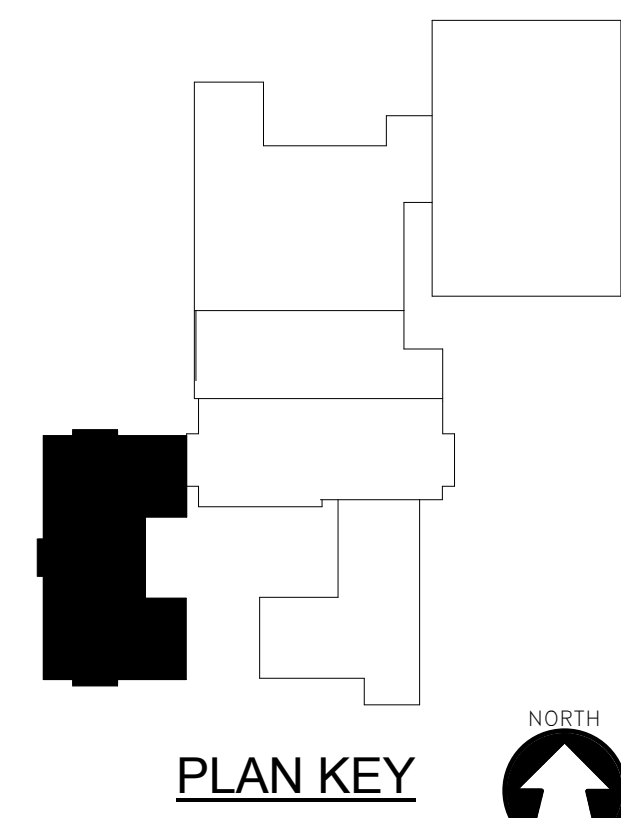

McMahon provides this drawing and data, regardless of form, as instruments of service. All rights including copyrights are retained by McMahon. The client and/or recipient agrees to the fullest extent permitted by law not to indemnify and hold McMahon harmless for any reuse of or changes made to the original drawing or data without prior written consent by McMahon.

DESIGNED RJW	DRAWN MAL
PROJECT NO. O0002-61600160	
DATE MARCH 3, 2017	
SHEET NO.	

EP231

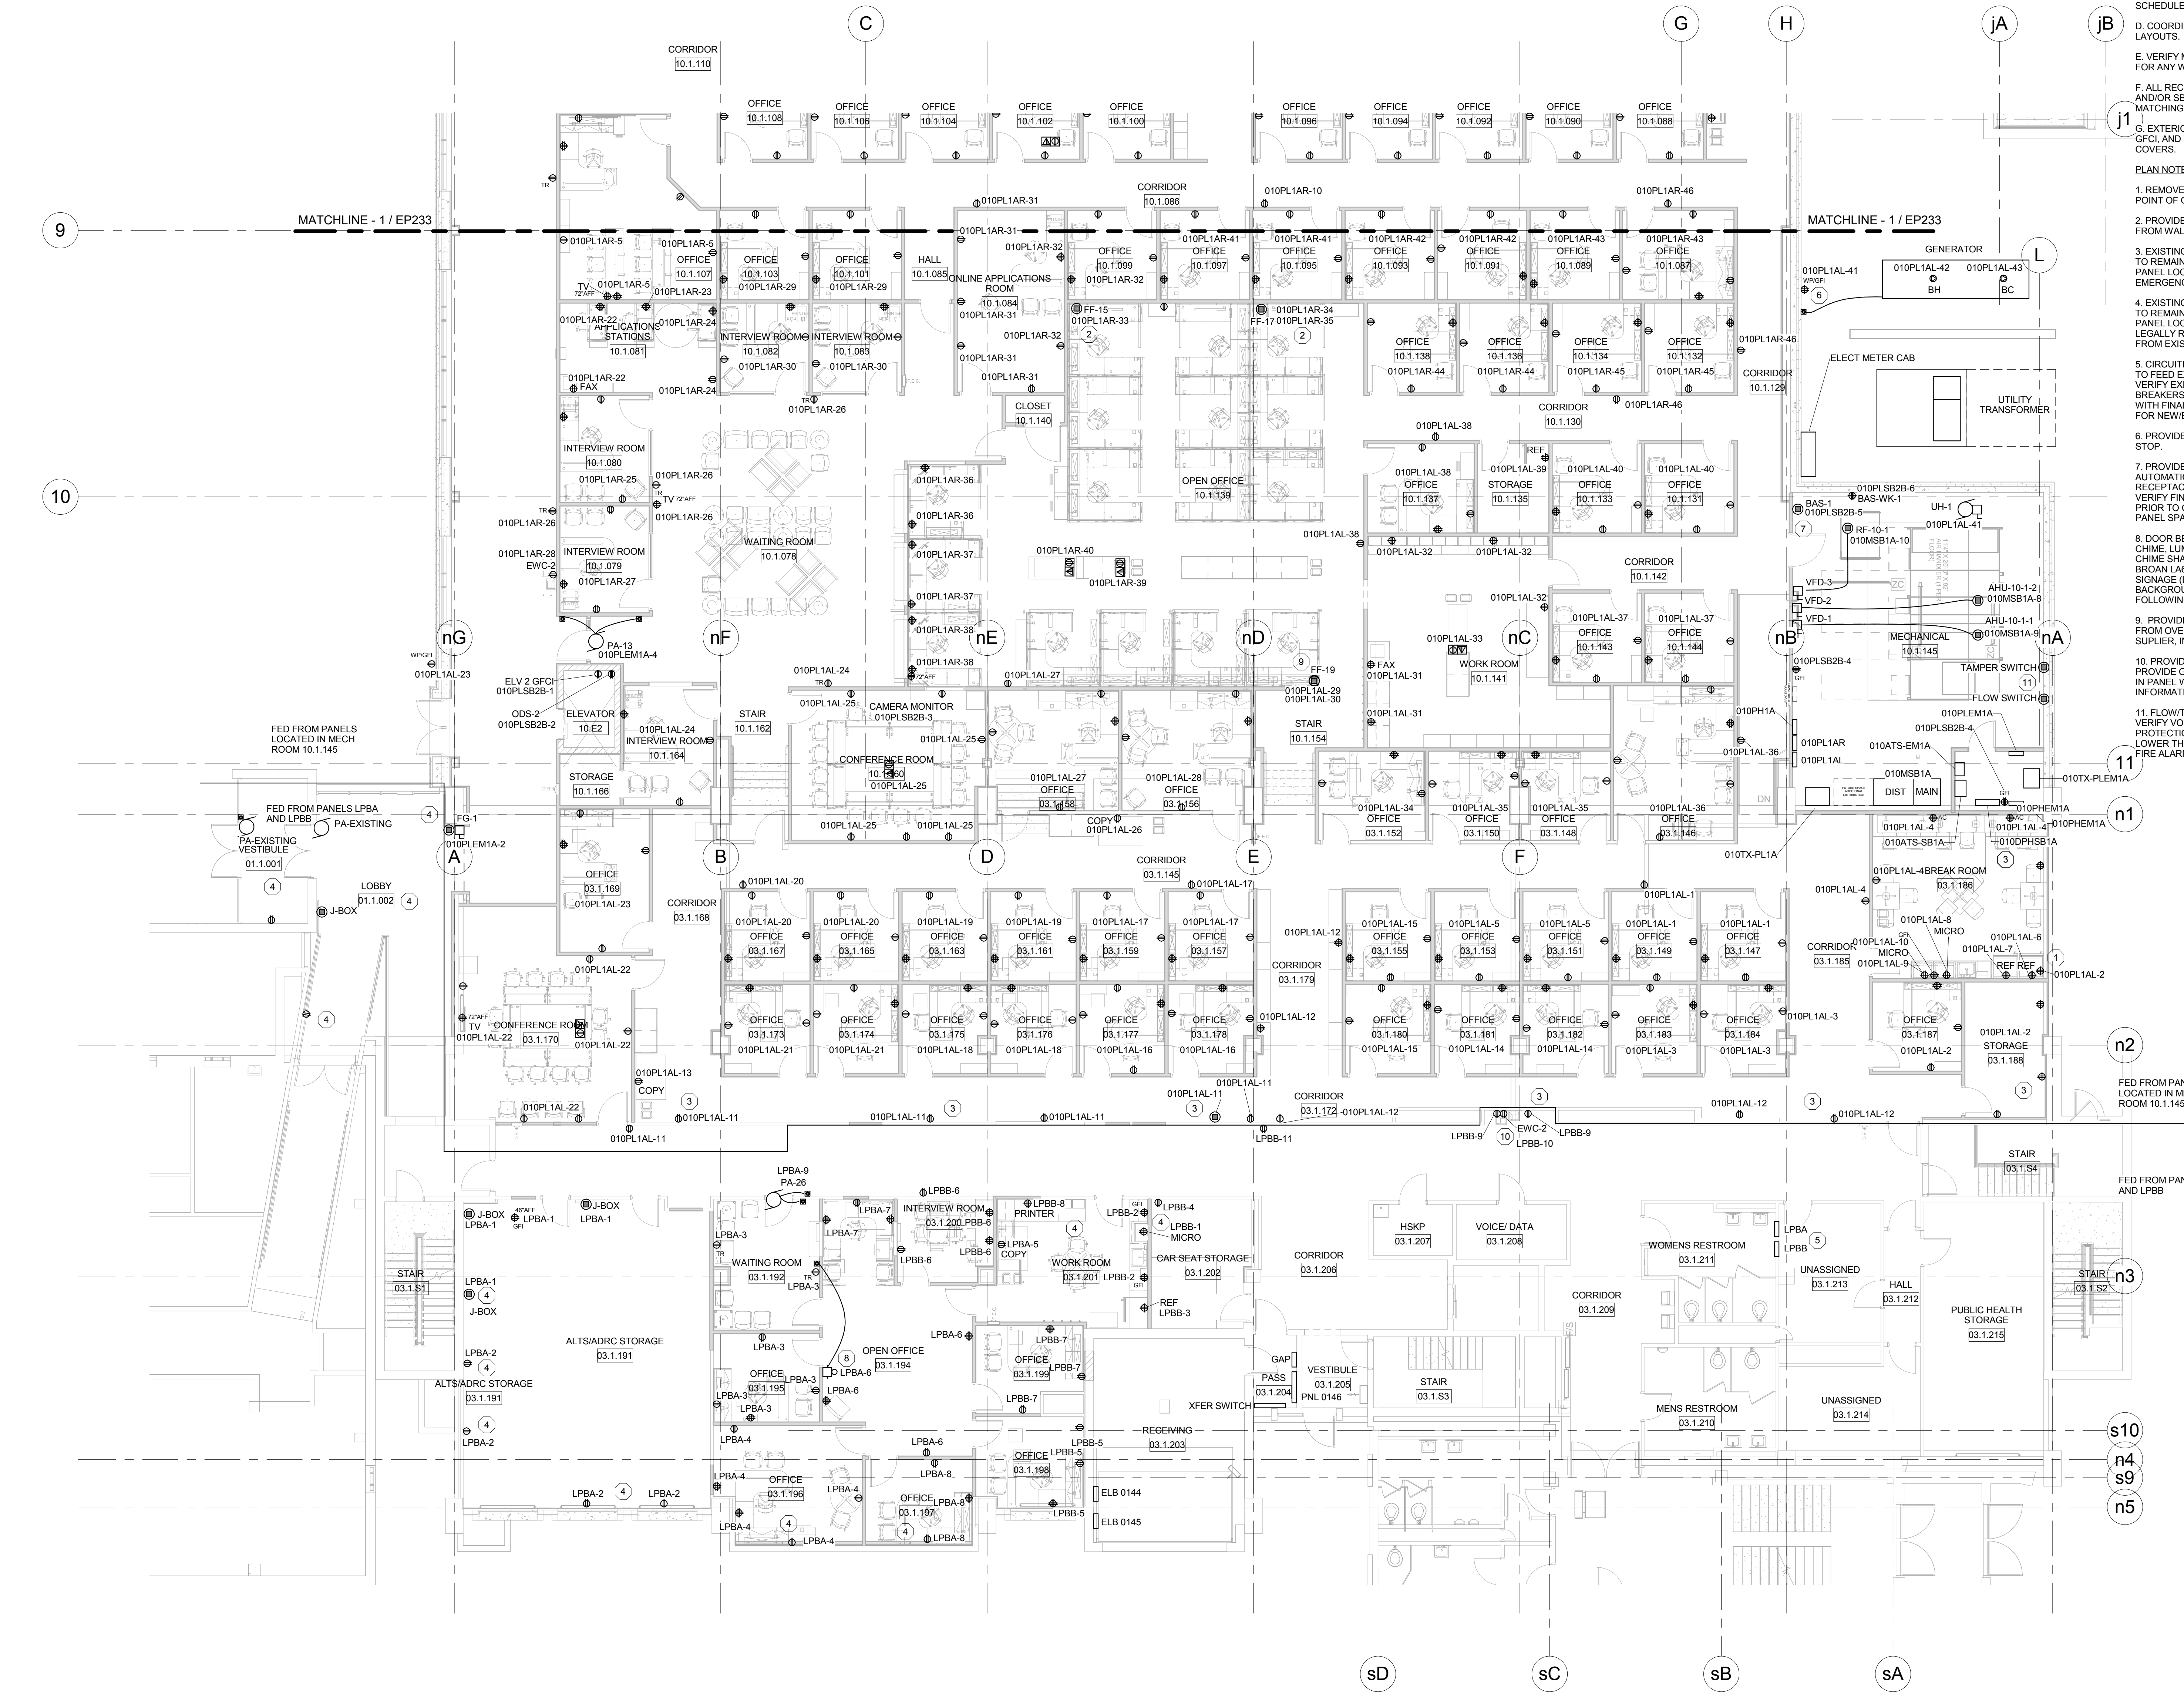


1 LEVEL 790.00 POWER PLAN-HHS NORTH/OCAC SOUTH
Scale: 1/8" = 1'-0"


- GENERAL NOTES:**
- UNLESS OTHERWISE INDICATED EXISTING TO REMAIN.
 - RECEPTACLES LOCATED WITHIN 6' OF SINK AND NOT READILY ACCESSIBLE SHALL BE FED WITH 20AMP GFCI BREAKER FROM LOCAL PANEL.
 - EXISTING DEVICES WHICH WILL REMAIN AFTER REMODEL, REPLACE DEVICES AND COVER PLATES TO MATCH NEW. PROVIDE NEW LABELING ON COVER PLATES AND BRANCH CIRCUIT WIRING. UPDATE DRAWINGS (AS-BUILTS) TO INDICATE DEVICES WHICH MAY HAVE BEEN LOCATED OTHER THAN INDICATED. PROVIDE NEW PANEL (MECHANICALLY TYPED) SCHEDULES FOR PANELS INDICATING WHERE EXISTING ARE FED FROM.
 - COORDINATE RECEPTACLE PLACEMENT WITH OFFICE FURNITURE LAYOUTS.
 - VERIFY MOUNTING HEIGHT WITH OWNER PRIOR TO INSTALLATION FOR ANY WALL MOUNTED MONITOR.
 - ALL RECEPTACLES WHICH ARE CONNECTED TO AN EMERGENCY (EM AND/OR SB) SYSTEM BRANCH CIRCUIT SHALL BE RED IN COLOR. PROVIDE MATCHING RED COVER PLATE FOR EACH DEVICE.
 - EXTERIOR RECEPTACLES WHEN INDICATED OUTDOORS SHALL BE GFCI AND WEATHER RESISTANT WITH METAL HEAVY DUTY IN-USE COVERS.

- PLAN NOTES: #**
- REMOVE EXISTING RECEPTACLE, CONDUIT AND WIRING BACK TO POINT OF ORIGIN. PROVIDE NEW BLANK STAINLESS STEEL COVER.
 - PROVIDE HARDWARE FURNITURE CONNECTION TO WORKSTATION FROM WALL LOCATION.
 - EXISTING DEVICES WHICH WERE NOT REMOVED DURING DEMO AND TO REMAIN. EXTEND EXISTING CONDUIT. PROVIDE NEW WIRING TO PANEL LOCATED IN MECHANICAL ROOM 10.1.145 FOR NORMAL, EMERGENCY OR LEGALLY REQUIRED DEVICES.
 - EXISTING DEVICES WHICH WERE NOT REMOVED DURING DEMO AND TO REMAIN. EXTEND EXISTING CONDUIT. PROVIDE NEW WIRING TO PANEL LOCATED IN MECHANICAL ROOM 10.1.145 FOR EMERGENCY OR LEGALLY REQUIRED DEVICES. DEVICES ON NORMAL POWER WILL BE FED FROM EXISTING PANEL LPBA, LPBB.
 - CIRCUITING INDICATED ON DRAWING INDICATES CIRCUITS REQUIRED TO FEED EXISTING AND NEW DEVICES. ELECTRICAL CONTRACTOR TO VERIFY EXISTING PANEL SPACE AND CIRCUIT LOCATION. PROVIDE BREAKERS, CONDUIT, AND WIRING AS REQUIRED. PROVIDE AS-BUILTS WITH FINAL CIRCUITING WITH A MECHANICALLY FILLED PANEL SCHEDULE FOR NEW/EXISTING LOADS IN EXISTING PANEL.
 - PROVIDE E-STOP, CONDUIT, AND WIRING TO REMOTE GENERATOR E-STOP.
 - PROVIDE AN EMERGENCY POWER CONNECTION TO (BAS) BUILDING AUTOMATION SYSTEM CONTROL PANEL AND WORK STATION RECEPTACLE (BAS-WK). PANEL PROVIDED AND INSTALLED BY OTHERS. VERIFY FINAL LOCATION WITH CONTRACTOR INSTALLING (BAS) SYSTEM PRIOR TO CONDUIT INSTALLATION. CURRENT LOCATION ACCOUNTS FOR PANEL SPACE, AND CONTROL PANEL CIRCUIT.
 - DOOR BELL. PROVIDE AND INSTALL A HARDWIRED, WALL MOUNTED CHIME. LUMINATED PUSHBUTTON, AND LOW VOLTAGE TRANSFORMER. CHIME SHALL INCLUDE BASIC TWO CHIME (TONE SETTING). UTILIZE BROAN LAB600WH DOORBELL KIT OR APPROVED EQUAL. PROVIDE SIGNAGE (LAMACOID LABEL) WITH 1/2" (BLACK) LETTERING ON A (WHITE) BACKGROUND LOCATE ABOVE PUSHBUTTON TO INDICATE THE FOLLOWING: "FOR ASSISTANCE PLEASE PUSH BUTTON".
 - PROVIDED HARDWARE FURNITURE CONNECTION TO WORKSTATION FROM OVERHEAD CEILING. POWER POLE PROVIDED BY FURNITURE SUPPLIER. INSTALLED AND TERMINATED BY ELECTRICAL CONTRACTOR.
 - PROVIDE CONNECTION TO NEW EMC-2 WATER COOLER AS NEEDED. PROVIDE GFCI PROTECTION TO ADDED COOLER BY MEANS OF BREAKER IN PANEL WHICH IS SERVING UNIT. SEE P212 FOR ADDITIONAL INFORMATION.
 - FLOW/TAMPER SWITCHES AND EXTERIOR NOTIFICATION DEVICES. VERIFY VOLTAGE CONNECTIONS WITH FIRE ALARM AND FIRE PROTECTION CONTRACTORS. WHERE THE REQUIRED VOLTAGE IS LOWER THAN 120VAC, ALL CONDUIT, WIRING WILL BE PROVIDED BY THE FIRE ALARM CONTRACTOR.

- REVISION**
- | NO. | DATE | DESCRIPTION |
|-----|------|-------------|
| 1 | | |
| 2 | | |
| 3 | | |
| 4 | | |
| 5 | | |
| 6 | | |
| 7 | | |
| 8 | | |
| 9 | | |
| 10 | | |
| 11 | | |

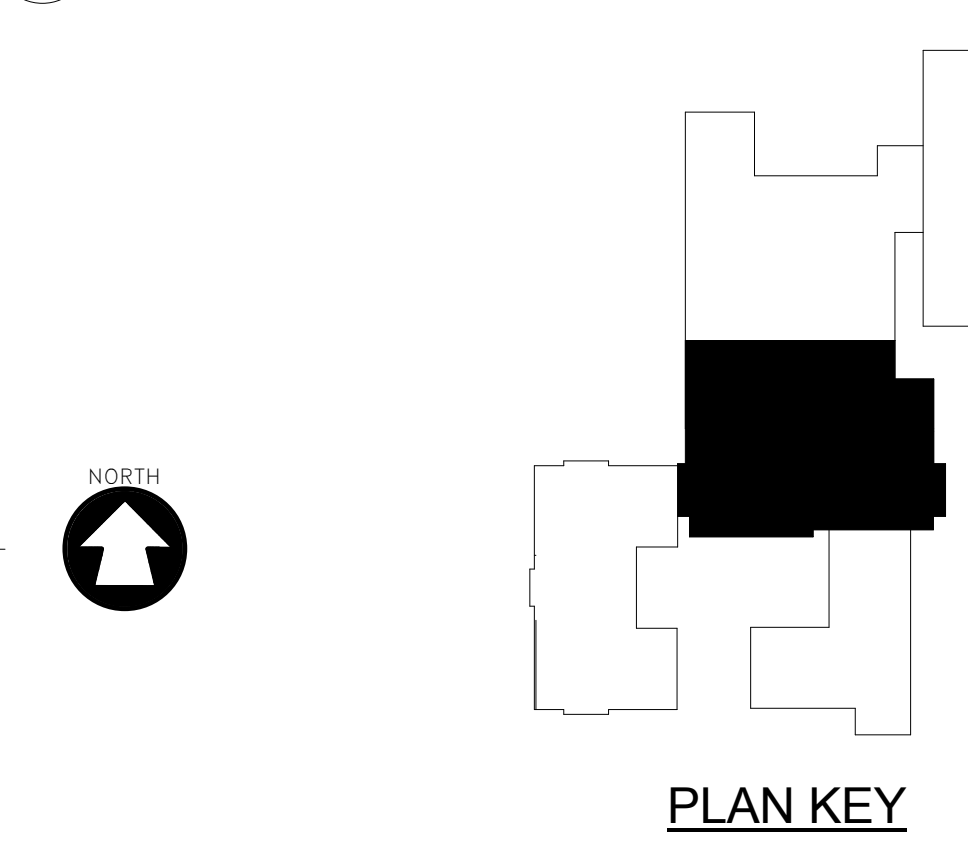

NO.	DATE	DESCRIPTION
1		
2		
3		
4		
5		
6		
7		
8		
9		
10		
11		

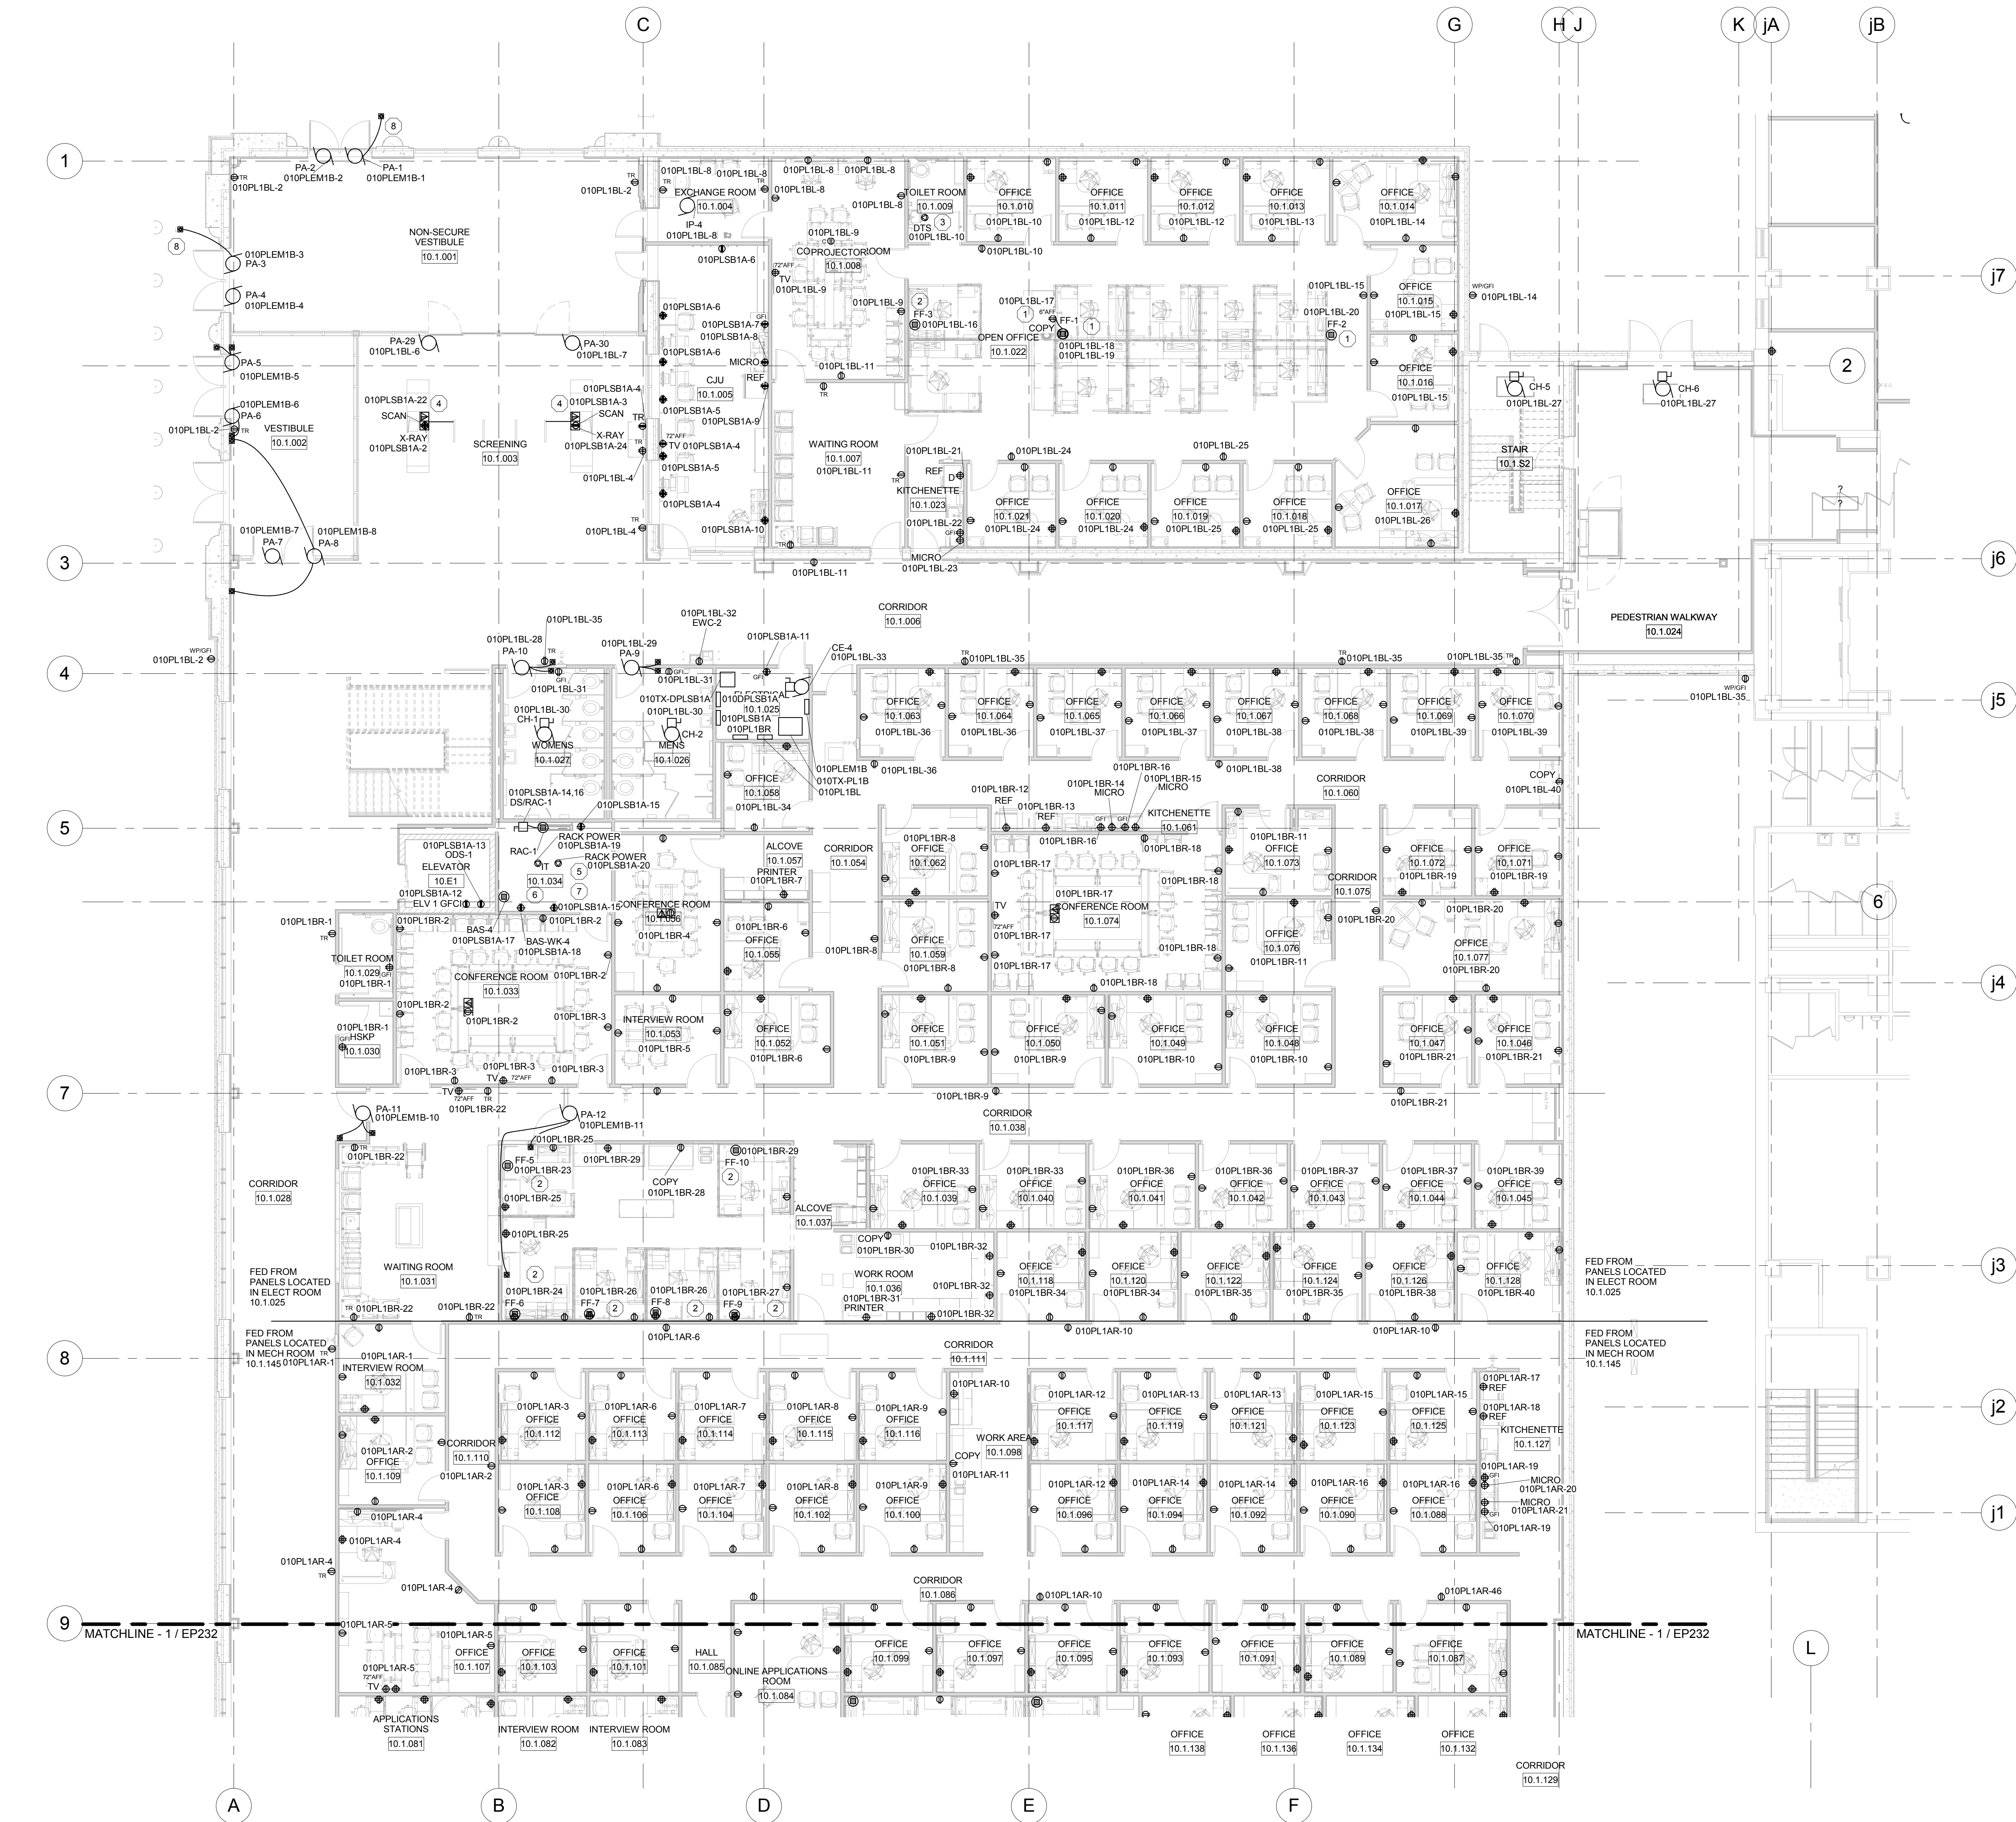


1 LEVEL 790.00 POWER PLAN-OCAC NORTH
Scale: 1/8" = 1'-0"

GENERAL NOTES:

- RECEPTACLES LOCATED WITHIN 6' OF SINK AND NOT READILY ACCESSIBLE SHALL BE FED WITH 20AMP GFCI BREAKER FROM LOCAL PANEL.
- COORDINATE RECEPTACLE PLACEMENT WITH OFFICE FURNITURE LAYOUTS.
- VERIFY MOUNTING HEIGHT WITH OWNER PRIOR TO INSTALLATION FOR ANY WALL MOUNTED MONITOR.
- ALL RECEPTACLES WHICH ARE CONNECTED TO AN EMERGENCY (EM AND/OR SB) SYSTEM BRANCH CIRCUIT SHALL BE RED IN COLOR. PROVIDE MATCHING RED COVER PLATE FOR EACH DEVICE.
- EXTERIOR RECEPTACLES WHEN INDICATED OUTDOORS SHALL BE GFCI AND WEATHER RESISTANT WITH METAL HEAVY DUTY IN-USE COVERS.

PLAN NOTES:

- FURNITURE FEED, PROVIDE OVERHEAD FEED FROM CEILING LOCATION. CONNECT (8) WORK STATIONS (4) PER CIRCUIT AND PRINTER WITH CIRCUITS INDICATED.
- PROVIDED HARDWIRE FURNITURE CONNECTION TO WORKSTATION FROM WALL LOCATION.
- PROVIDE SOLENOID CONNECTION AND OCCUPANCY CONNECTIONS TO CONTROL WATER VALVE WHEN DOOR IS CLOSED FOR TESTING TOILET.
- SCREENING, PROVIDE UNDERGROUND CONDUITS (1) POWER (1) DATA TO EACH FLOOR BOX LOCATION. DOUBLE DUPLEX RECEPTACLES FED WITH (2) SEPARATE BRANCH CIRCUITS FOR EACH X-RAY INSPECTION AND DETECTION SYSTEM. FLOOR BOXES SHALL BE INSTALLED WITH RECEPTACLES, AND DATA CONNECTIONS. SEE MANUFACTURER SPECIFICATION SHEETS PRIOR TO ROUGH IN AND INSTALLATION.
- COORDINATE RECEPTACLE PLACEMENT WITH FINAL EQUIPMENT LOCATIONS.
- PROVIDE AN EMERGENCY POWER CONNECTION TO (BAS) BUILDING AUTOMATION SYSTEM CONTROL PANEL AND WORK STATION RECEPTACLE (BAS-WI) PANEL PROVIDED AND INSTALLED BY OTHERS. VERIFY FINAL LOCATION WITH CONTRACTOR INSTALLING (BAS) SYSTEM PRIOR TO CONDUIT INSTALLATION. CURRENT LOCATION ACCOUNTS FOR PANEL SPACE, AND CONTROL PANEL CIRCUIT.
- PROVIDE 120VAC POWER CONNECTIONS TO THE FOLLOWING SECURITY, FIRE ALARM, AND SYSTEMS EQUIPMENT: (3) FA NACS PER FLOOR USING (1) 120VAC 15AMP CIRCUIT, (2) TRANSPODERS FOR THE DURESS SYSTEM, EACH USING (1) 120VAC 15AMP CIRCUIT, AND (3) POWER SUPPLIES FOR THE ACCESS CONTROL SYSTEM, EACH WITH 120VAC 15AMP CIRCUITS, (1) PAGING AMP PER FLOOR THAT WILL REQUIRE A 120V CIRCUIT TO A POWER SUPPLY PLUG IN TRANSFORMER WHICH CAN BE SUPPLIED FROM A RECEPTACLE. VERIFY SYSTEMS, SECURITY, AND FIRE ALARM DRAWINGS, AND PROVIDERS WHERE CIRCUITING WILL ORIGINATE FROM (NORMAL OR EMERGENCY SOURCES). PROVIDE BREAKERS AND BREAKER LOCKS AS SPECIFIED PER EQUIPMENT BEING INSTALLED. INDICATE ON AS-BUILT DRAWINGS AND PANEL SCHEDULES WHERE CIRCUITING FOR EQUIPMENT IS TERMINATED.
- POST MOUNTED ADA ASSIST. SEE DRAWING A274 FOR LOCATION.

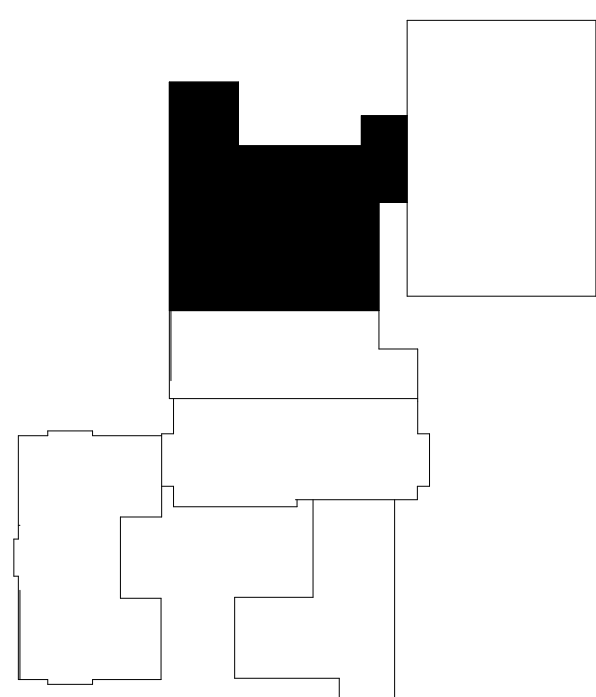

PLAN KEY

McMAHON
ENGINEERS ARCHITECTS
1000 N. 10TH ST., SUITE 200
MILWAUKEE, WI 53233
Tel: (414) 224-1200 Fax: (414) 224-1201
www.mahon.com

McMahon provides this drawing as a service to the client. It is not to be used for any other purpose without the written consent of McMahon. The client is responsible for the accuracy of the information provided and for the results of the work performed. McMahon is not responsible for the accuracy of the information provided or the results of the work performed by any other party.

DESIGNED BY: R.J.W.
DRAWN BY: MAL

PROJECT NO.: 00002-61600160

DATE: MARCH 3, 2017

SHEET NO.: EP233


ALTERATION / ADDITION
OUTAGAME COUNTY ADMINISTRATION CENTER
S. WALNUT & W. 8TH, APPLETON WI 54911
LEVEL 790.00 POWER PLAN-OCAC NORTH

DESIGNED BY: R.J.W.
DRAWN BY: MAL

PROJECT NO.: 00002-61600160

DATE: MARCH 3, 2017

SHEET NO.: EP233

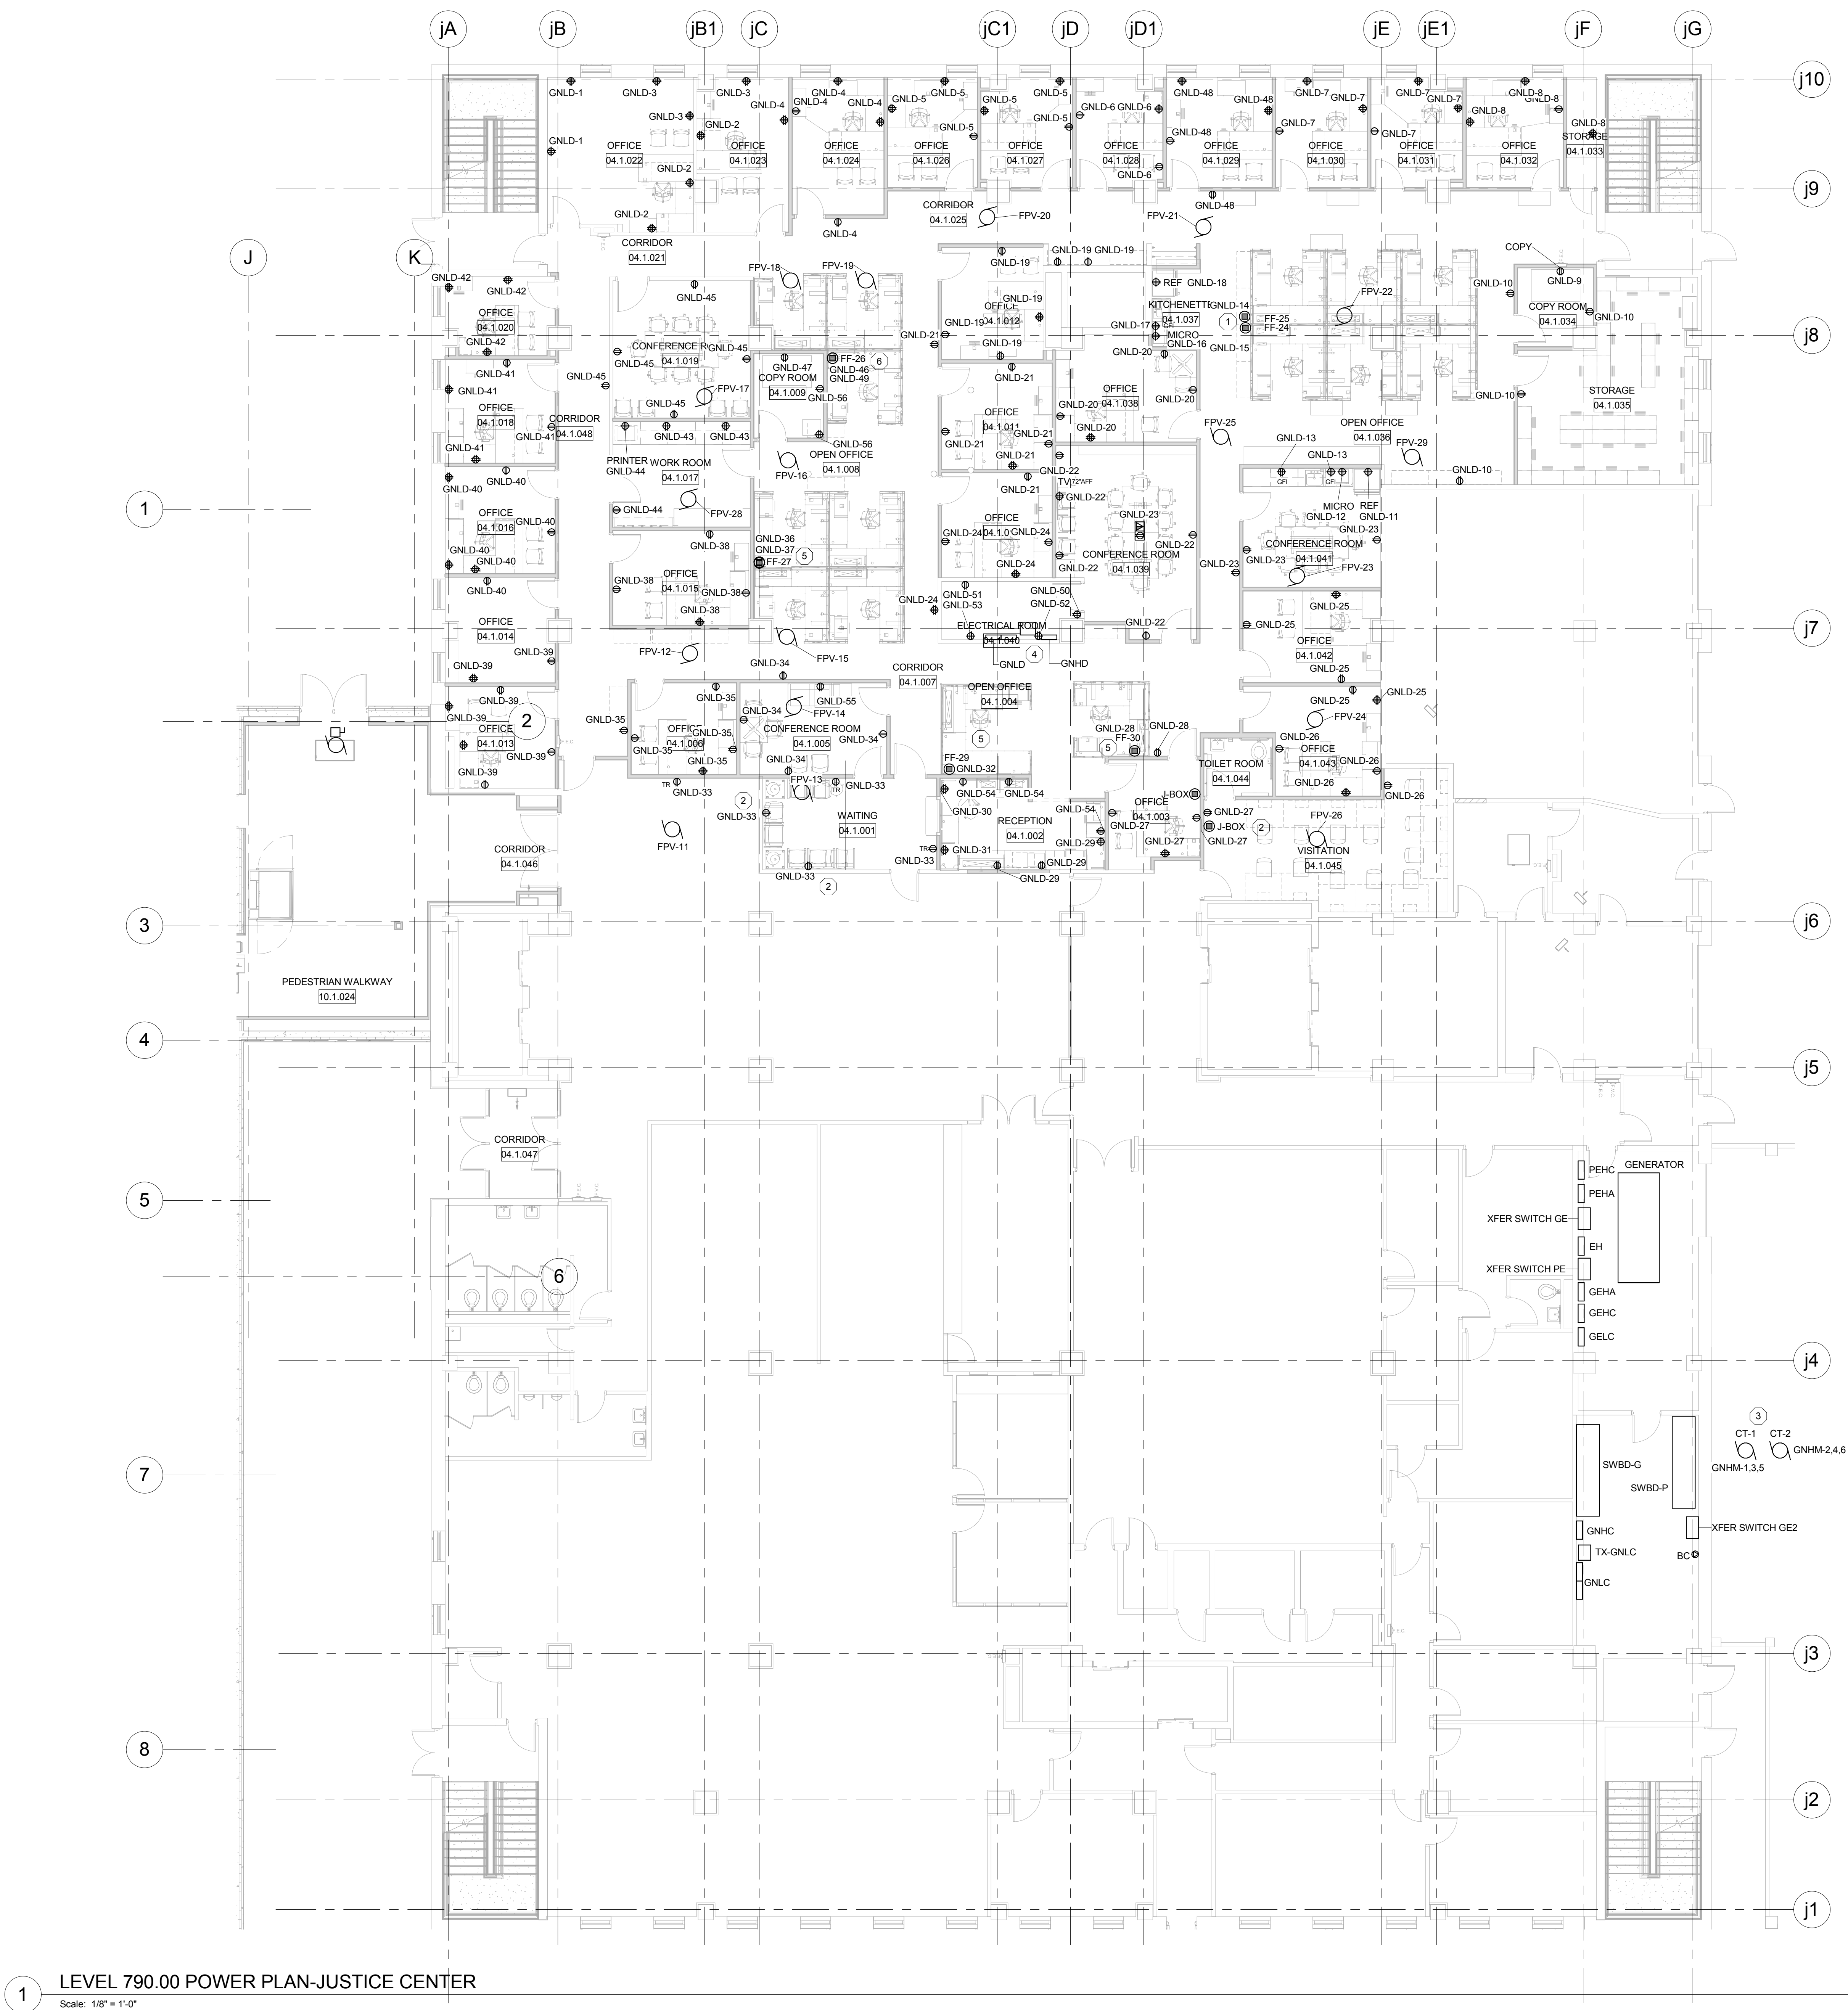


1 LEVEL 790.00 POWER PLAN-JUSTICE CENTER
Scale: 1/8" = 1'-0"

GENERAL NOTES:

- A. UNLESS OTHERWISE INDICATED EXISTING TO REMAIN.
- B. RECEPTACLES LOCATED WITHIN 6' OF SINK AND NOT READILY ACCESSIBLE SHALL BE FED WITH 20AMP GFCI BREAKER FROM LOCAL PANEL.
- C. EXISTING DEVICES WHICH WILL REMAIN AFTER REMODEL, REPLACE DEVICES AND COVER PLATES TO MATCH NEW. PROVIDE NEW LABELING ON COVER PLATES AND BRANCH CIRCUIT WIRING. UPDATE DRAWINGS (AS-BUILTS) TO INDICATE DEVICES WHICH MAY HAVE BEEN LOCATED OTHER THAN INDICATED. PROVIDE NEW PANEL (MECHANICALLY TYPED) SCHEDULES FOR PANELS INDICATING WHERE EXISTING ARE FED FROM.
- D. CIRCUITING INDICATED ON DRAWING INDICATES CIRCUITS REQUIRED TO FEED EXISTING AND NEW DEVICES. ELECTRICAL CONTRACTOR TO VERIFY EXISTING PANEL SPACE AND CIRCUIT LOCATION. PROVIDE BREAKERS, CONDUIT, AND WIRING AS REQUIRED. PROVIDE AS-BUILTS WITH FINAL CIRCUITING WITH A MECHANICALLY FILLED PANEL SCHEDULE FOR NEW/EXISTING LOADS IN EXISTING PANEL.
- E. DEVICES SUCH AS VENDING MACHINES, REFRIGERATORS, AND MICROWAVES WHICH ARE NOT READILY ACCESSIBLE AND/OR LOCATED WITHIN 6' OF SINK SHALL BE FED FROM GFCI BREAKER.
- F. ALL BREAKERS SHALL BE 20 AMP UNLESS INDICATED OTHERWISE.
- G. WATER COOLERS, WHERE PRESENT, SHALL BE FED FROM A GFCI BREAKER.
- H. EXISTING DEVICES WHICH WERE NOT REMOVED DURING DEMO AND TO REMAIN. EXTEND EXISTING CONDUIT, PROVIDE NEW WIRING TO EXISTING PANELS.
- I. VERIFY MOUNTING HEIGHT WITH OWNER PRIOR TO INSTALLATION FOR ANY WALL MOUNTED MONITOR.
- J. ALL RECEPTACLES WHICH ARE CONNECTED TO AN EMERGENCY (EM AND/OR SB) SYSTEM BRANCH CIRCUIT SHALL BE RED IN COLOR. PROVIDE MATCHING RED COVER PLATE FOR EACH DEVICE.

PLAN NOTES:

- FURNITURE FEED, PROVIDE OVERHEAD FEED FROM CEILING LOCATION, CONNECT (B) WORK STATIONS (S) PER CIRCUIT POWER POLE PROVIDED BY FURNITURE SUPPLIER, INSTALLED AND TERMINATED BY ELECTRICAL CONTRACTOR.
- EXISTING DEVICES CHANGED TO TAMPER PROOF.
- REFER TO HVAC DRAWINGS H225 FOR EXACT LOCATIONS.
- EXISTING TO REMAIN.
- PROVIDE HARDWARE FURNITURE CONNECTION TO WORKSTATION FROM OVERHEAD CEILING. POWER POLE PROVIDED BY FURNITURE SUPPLIER, INSTALLED AND TERMINATED BY ELECTRICAL CONTRACTOR.

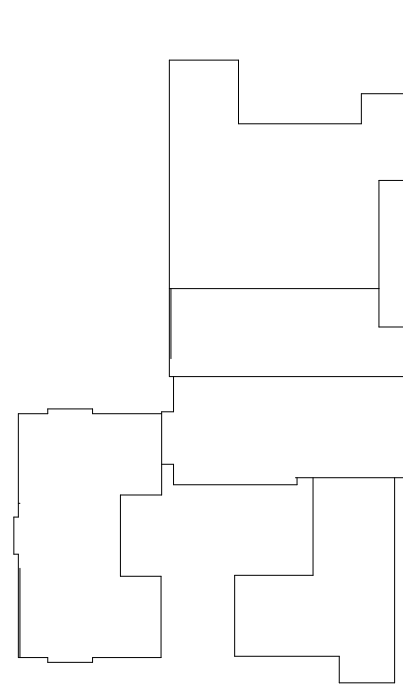

PLAN KEY

McMAHON
ENGINEERS ARCHITECTS
1000 N. WALNUT ST., SUITE 200
MILWAUKEE, WI 53233
Tel: (414) 224-1234 Fax: (414) 224-1235
www.mahon.com

McMahon provides this drawing as an instrument of service. All work shall be in accordance with the contract documents. The Client shall be responsible for obtaining all necessary permits and for the safety of the work. McMahon is not responsible for any damage to existing conditions or for any delay or cost increase resulting from any change made to the original design or construction.

REVISION

DATE

NO.

ALTERATION / ADDITION
OUTAGAME COUNTY ADMINISTRATION CENTER
S. WALNUT & W. 8TH, APPLETON WI 54911
LEVEL 790.00 POWER PLAN-JUSTICE CENTER

DESIGNED R.J.W.	DRAWN MAL
PROJECT NO. 00002-61600160	
DATE MARCH 3, 2017	
SHEET NO.	

EP234




McMahon provides this drawing and data, regardless of form, as instruments of service. All rights including copyrights are retained by McMahon. The client and/or recipient agrees to the fullest extent permitted by law to indemnify and hold McMahon harmless for any reuse of or changes made to the original drawing or data without prior

[illegible]

ALTERATION / ADDITION

DESIGNED		DRAWN	
RJW		MAL	
PROJECT NO.			
C0002-61600160			
DATE			
MARCH 3, 2017			
SHEET NO.			
EP235			

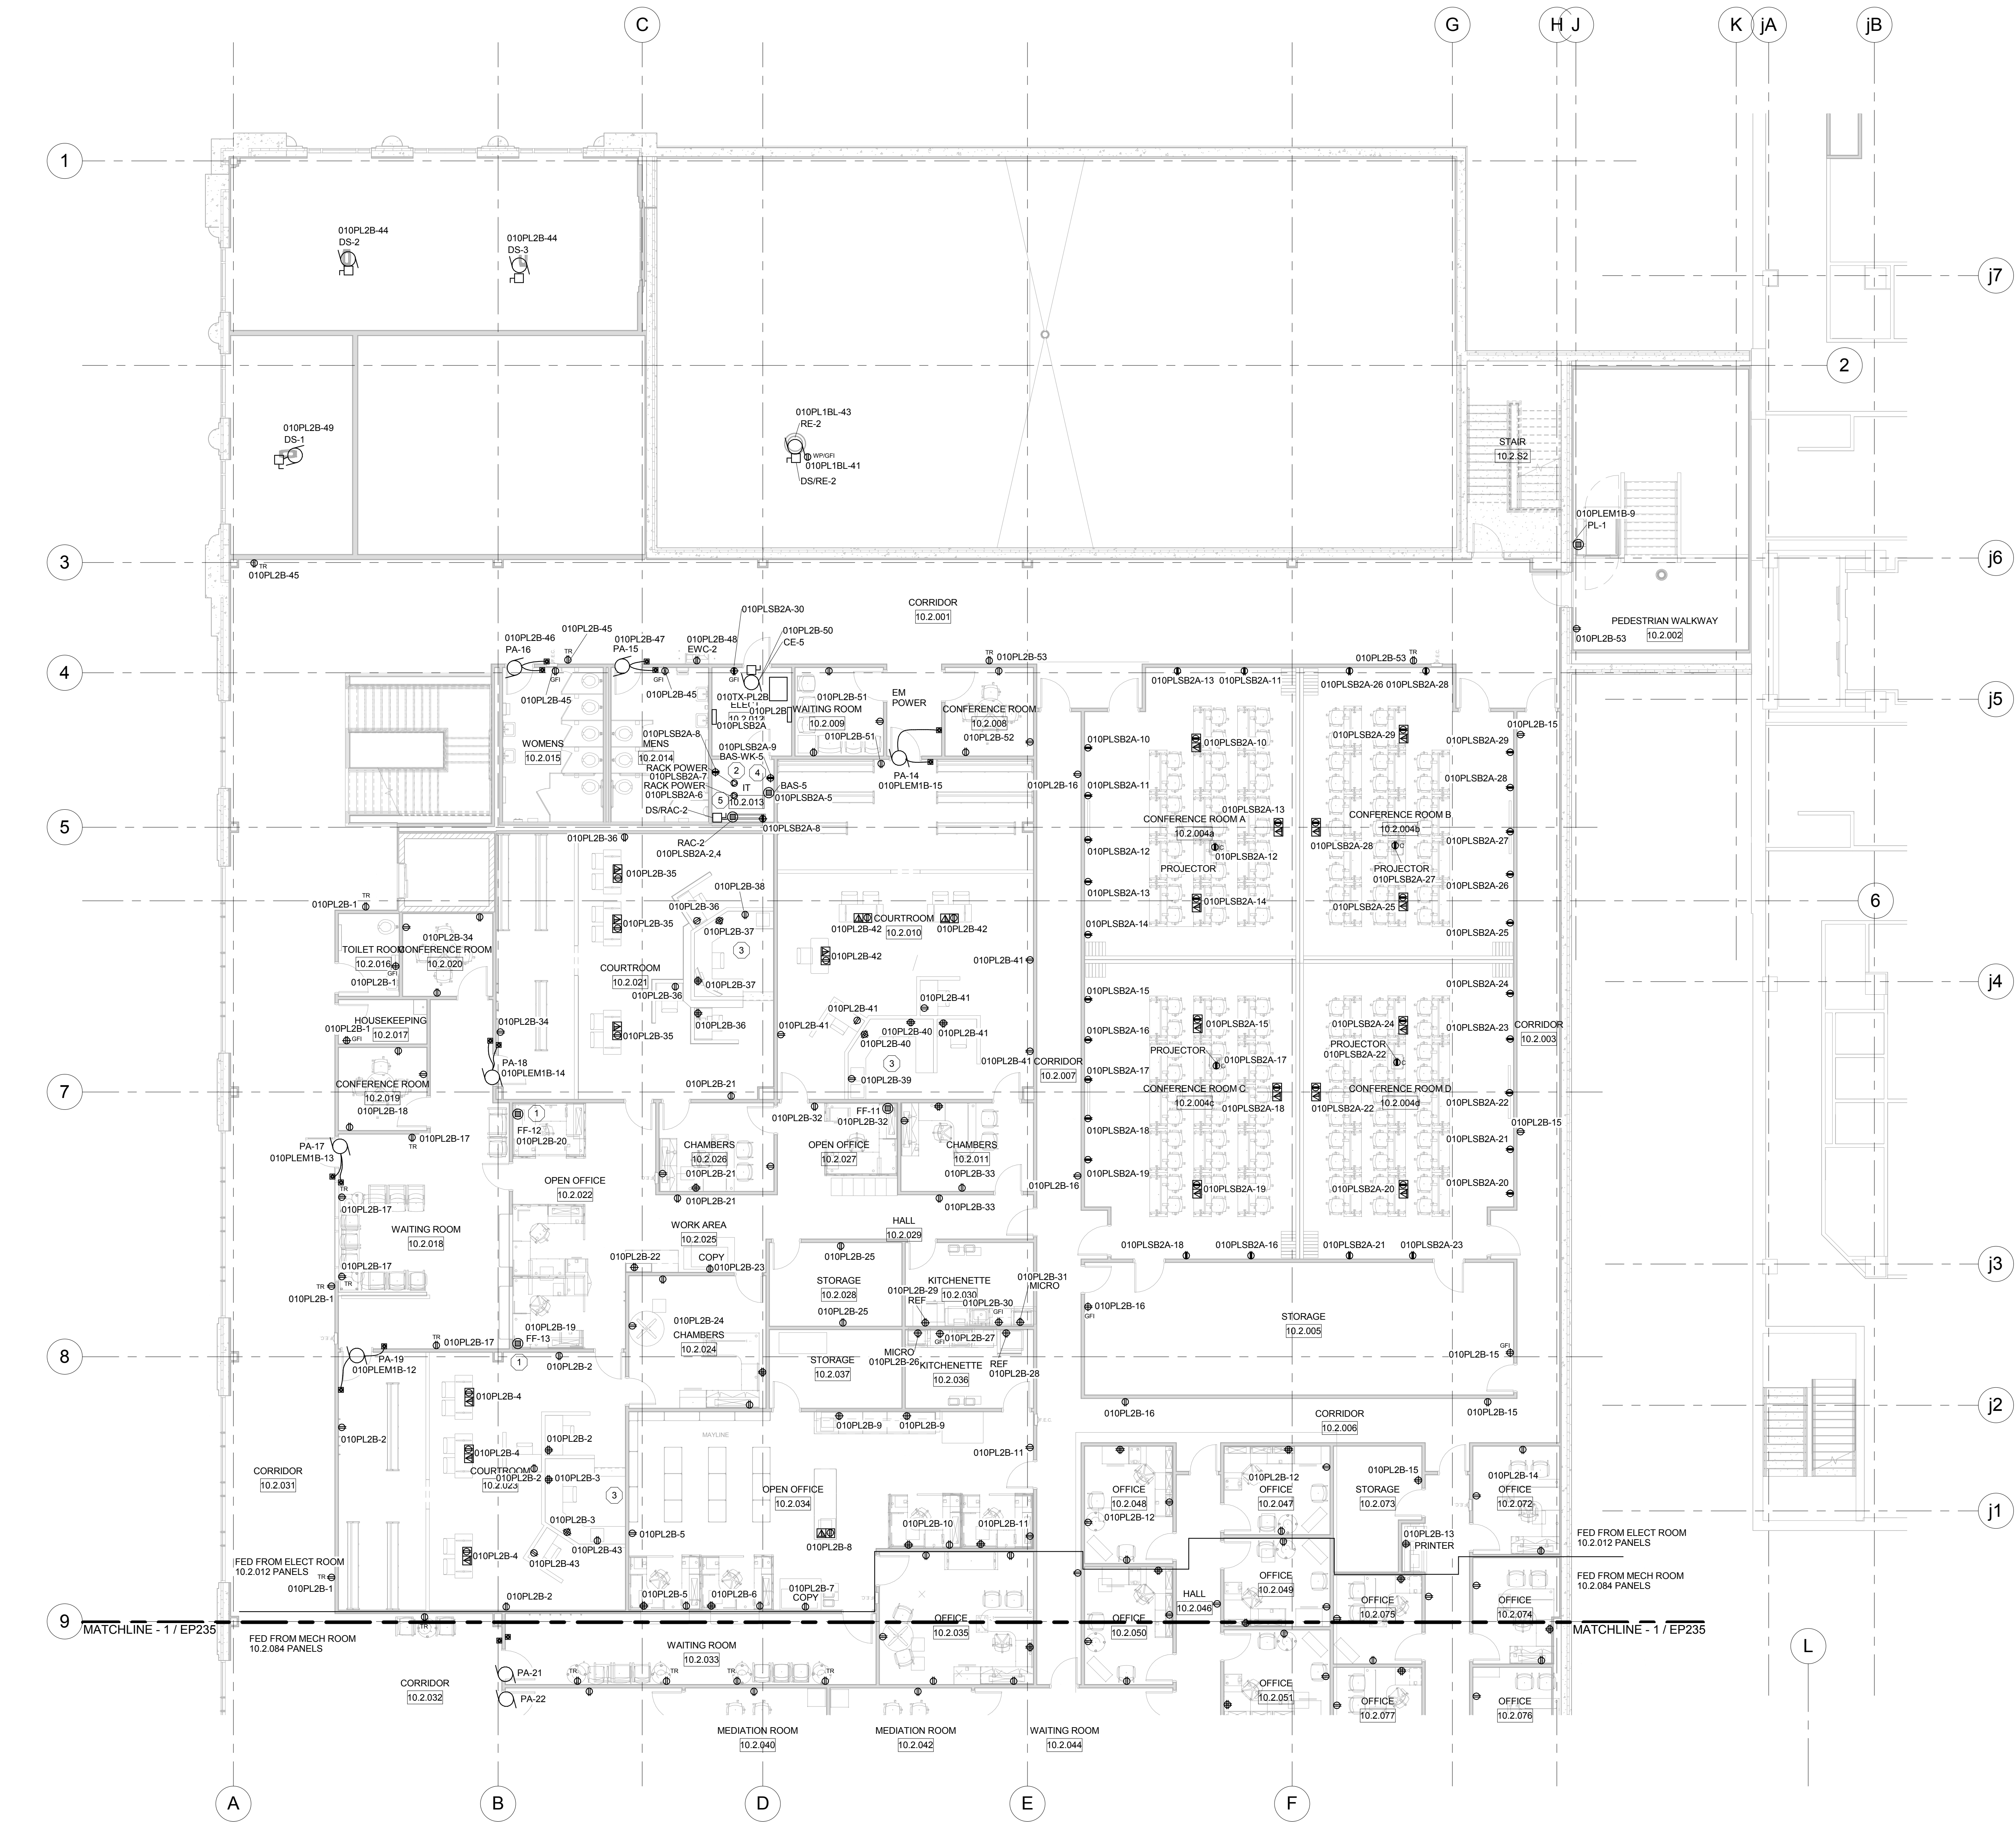

1 LEVEL 805.00 POWER PLAN-OCAC NORTH
Scale: 1/8" = 1'-0"

GENERAL NOTES:

A. RECEPTACLES LOCATED WITHIN 6' OF SINK AND NOT READILY ACCESSIBLE SHALL BE FED WITH 20AMP GFCI BREAKER FROM LOCAL PANEL.

B. COORDINATE FLOOR BOX LOCATION PRIOR TO INSTALLATION.

C. COORDINATE RECEPTACLE PLACEMENT WITH OFFICE FURNITURE LAYOUTS.

D. VERIFY MOUNTING HEIGHT WITH OWNER PRIOR TO INSTALLATION FOR ANY WALL MOUNTED MONITOR.

E. ALL RECEPTACLES WHICH ARE CONNECTED TO AN EMERGENCY (EM AND/OR SB) SYSTEM BRANCH CIRCUIT SHALL BE RED IN COLOR. PROVIDE MATCHING RED COVER PLATE FOR EACH DEVICE.

PLAN NOTES: (#)



1. PROVIDED HARDWIRE FURNITURE CONNECTION TO WORKSTATION FROM WALL LOCATION.

2. COORDINATE RECEPTACLE PLACEMENT WITH FINAL EQUIPMENT LOCATIONS.

3. DEVICE MOUNTED 1" ABOVE RAISED FLOOR (FINISHED).

4. PROVIDE AN EMERGENCY POWER CONNECTION TO (BAS) BUILDING AUTOMATION SYSTEM CONTROL PANEL AND WORK STATION RECEPTACLE (BAS-WK) PANEL PROVIDED AND INSTALLED BY OTHERS. VERIFY FINAL LOCATION WITH CONTRACTOR INSTALLING (BAS) SYSTEM PRIOR TO CONDUIT INSTALLATION. CURRENT LOCATION ACCOUNTS FOR PANEL SPACE, AND CONTROL PANEL CIRCUIT.

5. PROVIDE 120VAC POWER CONNECTIONS TO THE FOLLOWING SECURITY, FIRE ALARM, AND SYSTEMS EQUIPMENT: (3) FA NAC'S PER FLOOR USING (1) 120VAC 15AMP CIRCUIT, (2) TRANSPONDER'S FOR THE DURESS SYSTEM, EACH USING (1) 120VAC 15AMP CIRCUIT, AND (3) POWER SUPPLIES FOR THE ACCESS CONTROL SYSTEM, EACH WITH 120VAC 15AMP CIRCUITS. (1) PAGING AMP PER FLOOR THAT WILL REQUIRE A 120V CIRCUIT TO A POWER SUPPLY PLUG IN TRANSFORMER WHICH CAN BE SUPPLIED FROM A RECEPTACLE. VERIFY SYSTEMS, SECURITY, AND FIRE ALARM DRAWINGS, AND PROVIDERS WHERE CIRCUITING WILL ORIGINATE FROM (NORMAL OR EMERGENCY SOURCES). PROVIDE BREAKERS AND BREAKER LOCKS AS SPECIFIED PER EQUIPMENT BEING INSTALLED. INDICATE ON AS-BUILT DRAWINGS AND PANEL SCHEDULES WHERE CIRCUITING FOR EQUIPMENT IS TERMINATED.

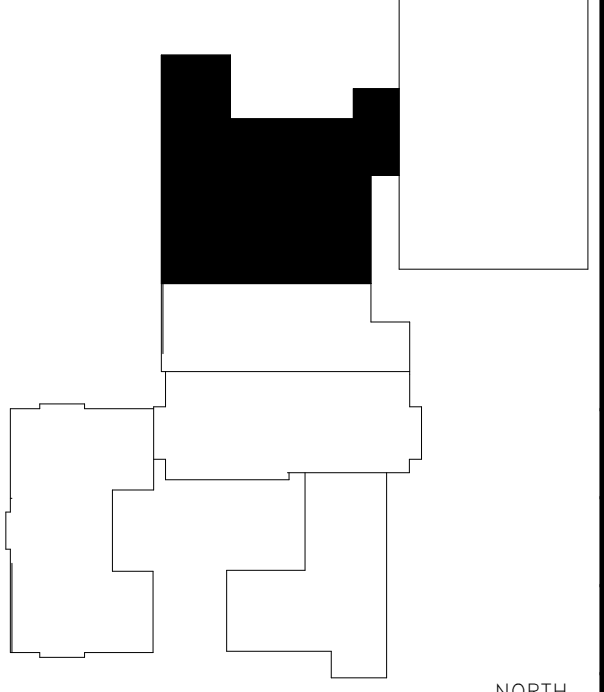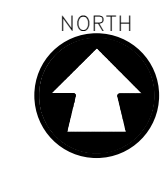


McMAHON
ENGINEERS ARCHITECTS
Main Office: 1025 N. Main St., Appleton, WI 54911
Tel: (920) 751-4200 Fax: (920) 751-4284
www.mahon.com

REVISION	
NO.	DATE

ALTERATION / ADDITION
OUTAGAMIE COUNTY ADMINISTRATION CENTER
S. WALNUT & W. 8TH, APPLETON WI 54911
LEVEL 805.00 POWER PLAN-OCAC NORTH


DESIGNED R.J.W.	DRAWN MAL
PROJECT NO. 00002-61600160	
DATE MARCH 3, 2017	
SHEET NO. EP236	

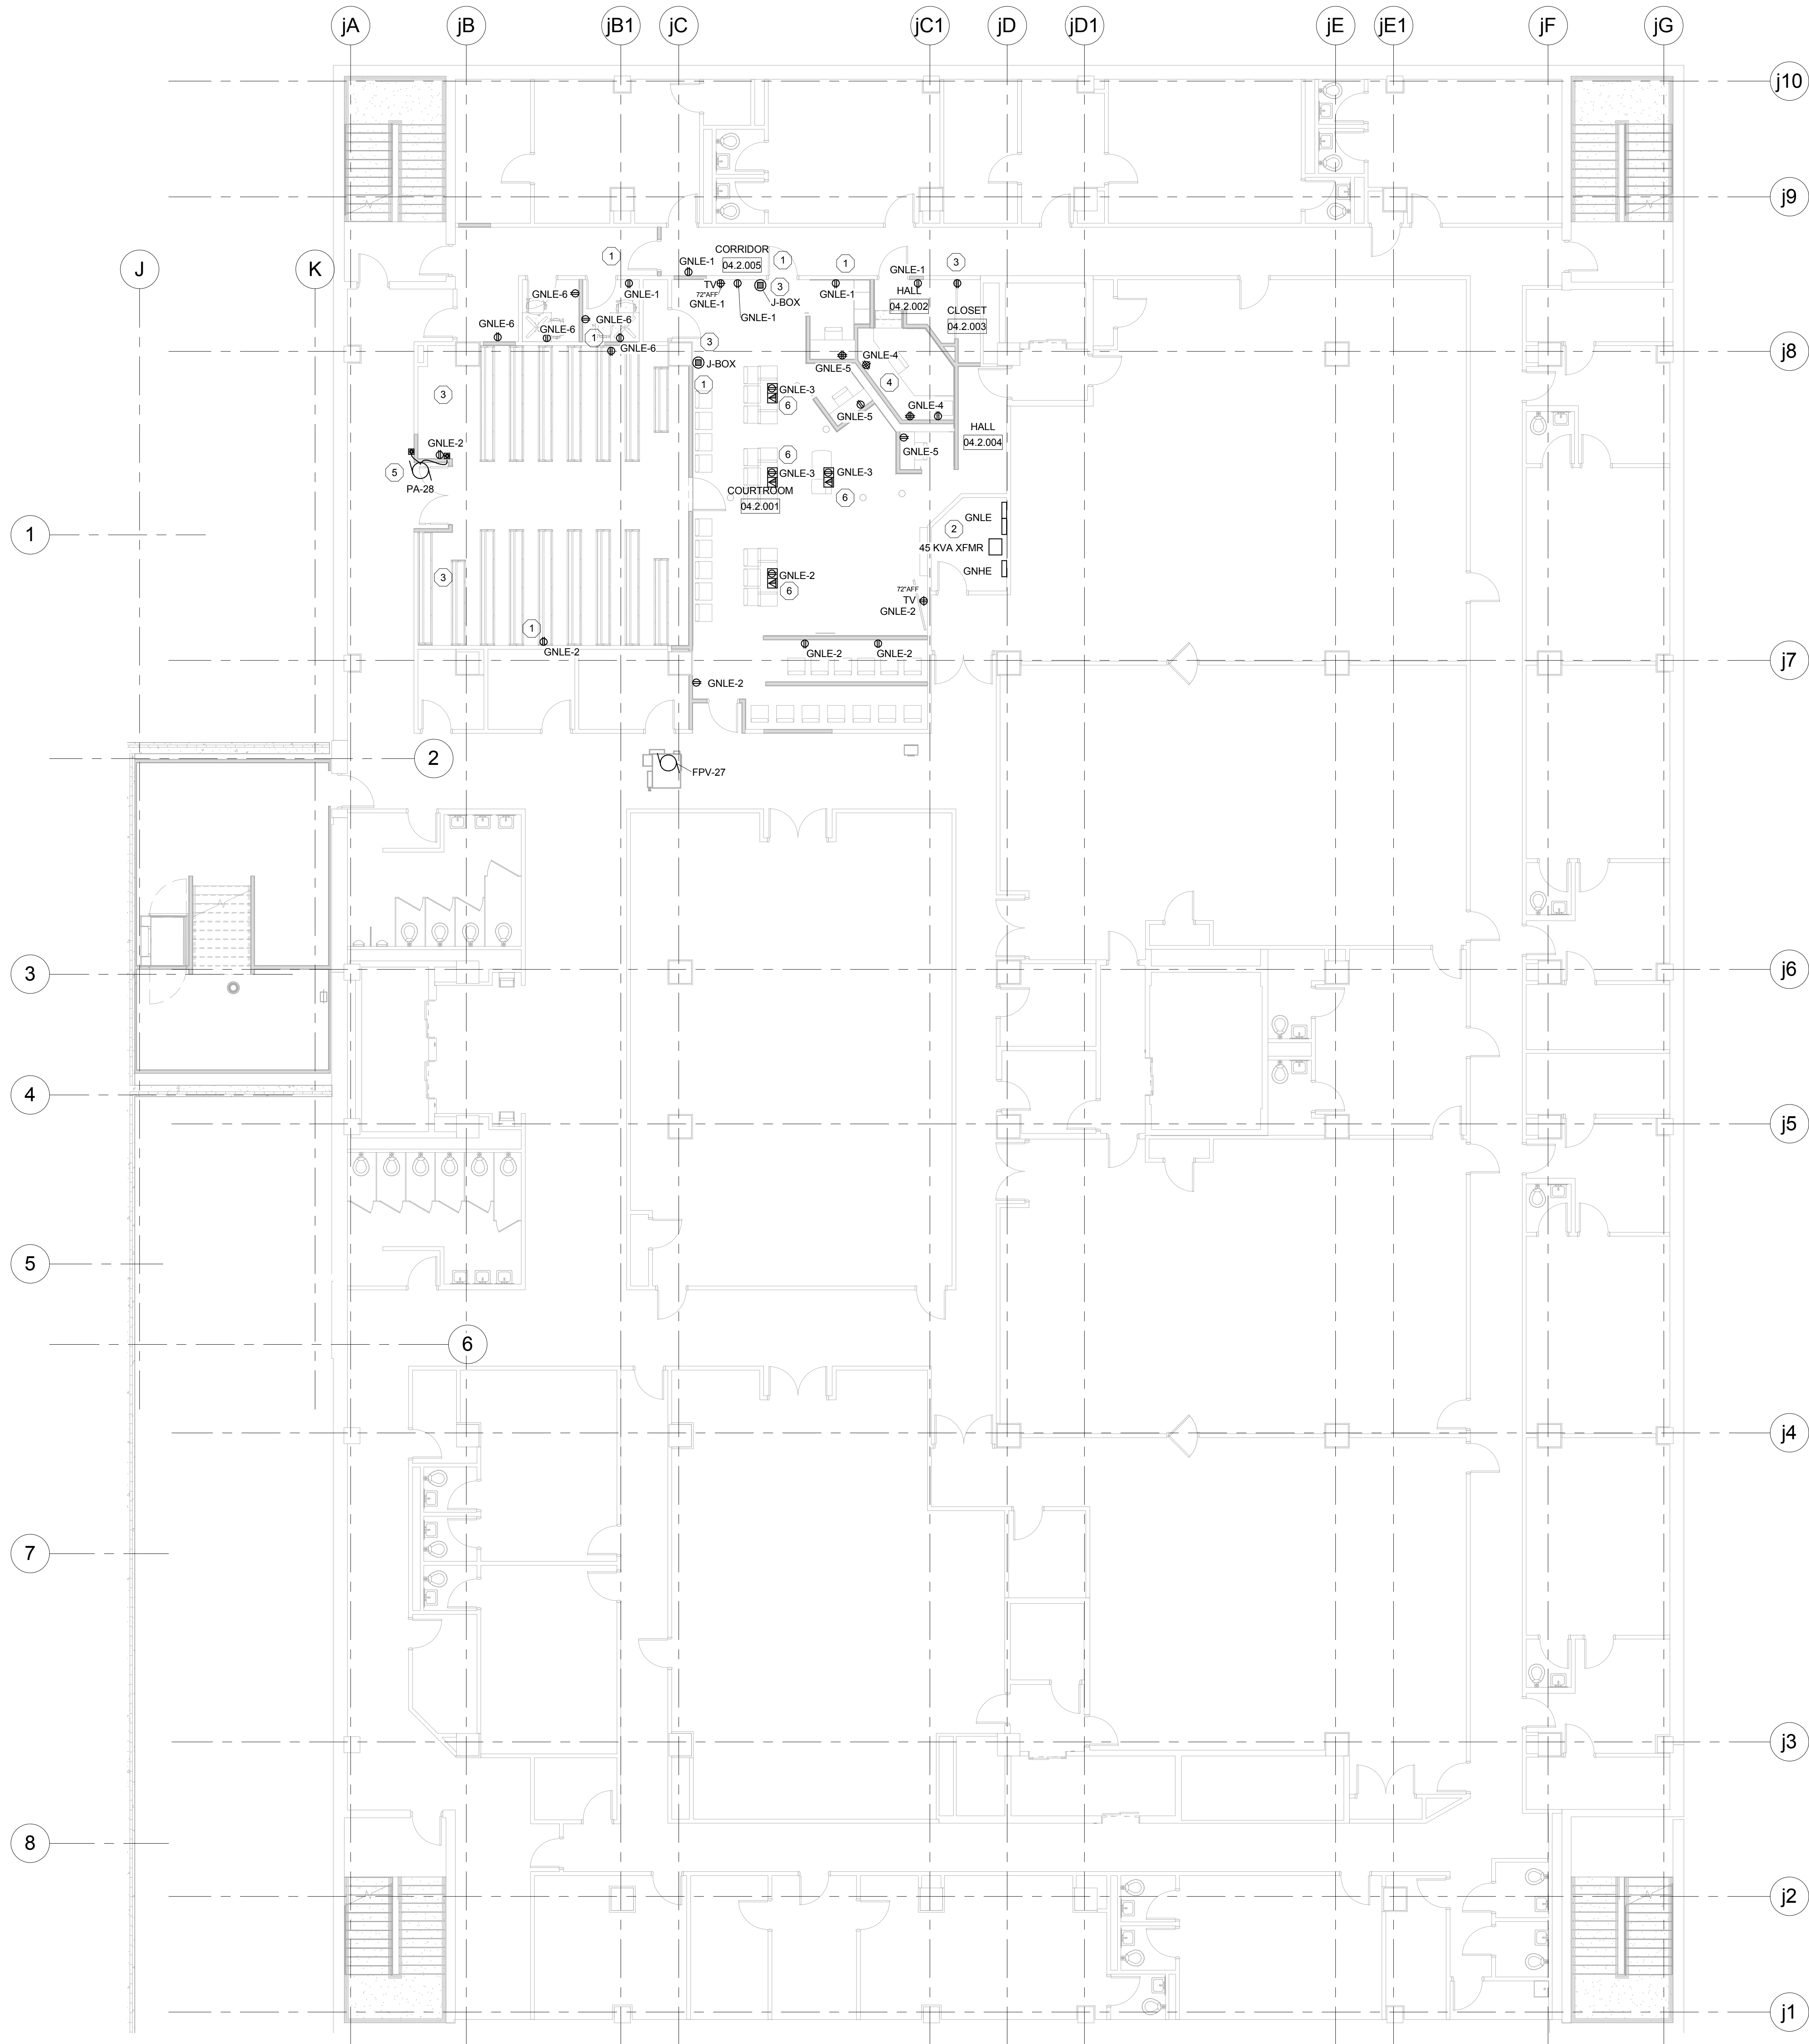


1 LEVEL 805.00 POWER PLAN-JUSTICE CENTER
Scale: 1/8" = 1'-0"

- GENERAL NOTES:**
- A. UNLESS OTHERWISE INDICATED EXISTING TO REMAIN.
- B. RECEPTACLES LOCATED WITHIN 6' OF SINK AND NOT READILY ACCESSIBLE SHALL BE FED WITH 20AMP GFCI BREAKER FROM LOCAL PANEL.
- C. EXISTING DEVICES WHICH WILL REMAIN AFTER REMODEL, REPLACE DEVICES AND COVER PLATES TO MATCH NEW, PROVIDE NEW LABELING ON COVER PLATES, BRANCH CIRCUIT WIRING, UPDATE DRAWINGS (AS-BUILTS) TO INDICATE DEVICES WHICH MAY HAVE BEEN LOCATED OTHER THAN INDICATED, PROVIDE NEW PANEL (MECHANICALLY TYPED) SCHEDULES FOR PANELS INDICATING WHERE EXISTING ARE FED FROM.
- D. CIRCUITING INDICATED ON DRAWING INDICATES CIRCUITS REQUIRED TO FEED EXISTING AND NEW DEVICES. ELECTRICAL CONTRACTOR TO VERIFY EXISTING PANEL SPACE AND CIRCUIT LOCATION, PROVIDE BREAKERS, CONDUIT, AND WIRING AS REQUIRED, PROVIDE AS-BUILTS WITH FINAL CIRCUITING WITH A MECHANICALLY FILLED PANEL SCHEDULE FOR NEW/EXISTING LOADS IN EXISTING PANEL.
- E. DEVICES SUCH AS VENDING MACHINES, REFRIGERATORS, AND MICROWAVES WHICH ARE NOT READILY ACCESSIBLE AND/OR LOCATED WITHIN 6' OF SINK SHALL BE FED FROM GFCI BREAKER.
- F. ALL BREAKERS SHALL BE 20 AMP UNLESS INDICATED OTHERWISE.
- G. WATER COOLERS, WHERE PRESENT, SHALL BE FED FROM A GFCI BREAKER.
- H. VERIFY MOUNTING HEIGHT WITH OWNER PRIOR TO INSTALLATION FOR ANY WALL MOUNTED MONITOR.
- I. ALL RECEPTACLES WHICH ARE CONNECTED TO AN EMERGENCY (EM AND/OR SB) SYSTEM BRANCH CIRCUIT SHALL BE RED IN COLOR, PROVIDE MATCHING RED COVER PLATE FOR EACH DEVICE.

- PLAN NOTES: #**
1. EXISTING DEVICES WHICH WERE NOT REMOVED DURING DEMO AND TO REMAIN, EXTEND EXISTING CONDUIT, PROVIDE NEW WIRING TO EXISTING PANELS.
2. EXISTING TO REMAIN.
3. PROVIDE NEW BLANK COVER AT BOX LOCATION.
4. DEVICE MOUNTED 18" ABOVE RAISED FLOOR (FINISHED).
5. PROVIDE AN EMERGENCY CIRCUIT FROM LOCAL EM PANEL, UPDATE PANEL SCHEDULE (PROVIDE MECHANICALLY NEW), UPDATE AS-BUILTS TO INDICATE WHERE FED FROM.
6. PROVIDE RECESSED, FIRE-RATED POKE-THROUGH FLOOR TYPE BOX WITH CAST ALUMINUM COVERS, FLOOR BOX AND COVER APPROVAL, BASED ON SUBMITTAL DOCUMENTATION PROVIDED PRIOR TO INSTALLATION, PROVIDE FLOOR X-RAY PRIOR TO PENETRATING FLOOR TO ENSURE LOCATION OF HOLE FOR FLOOR BOX WILL NOT COMPROMISE THE FLOOR'S INTEGRITY.

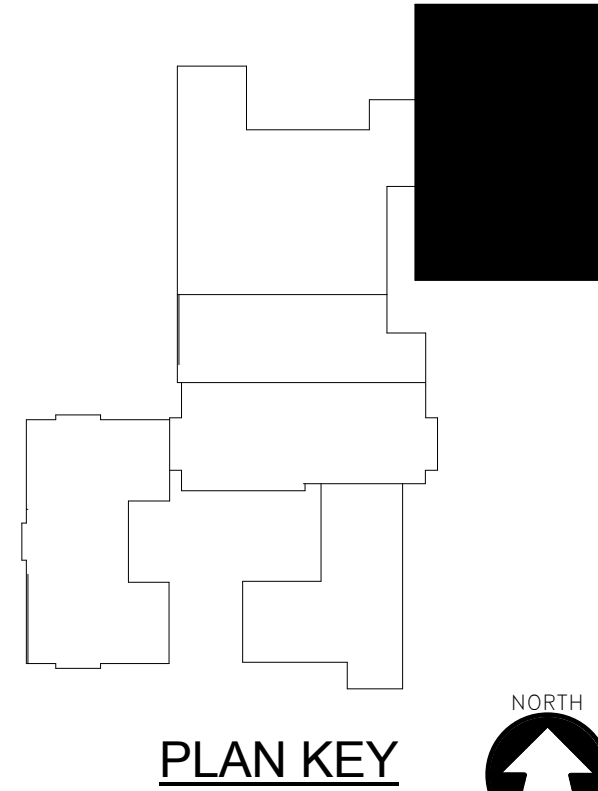

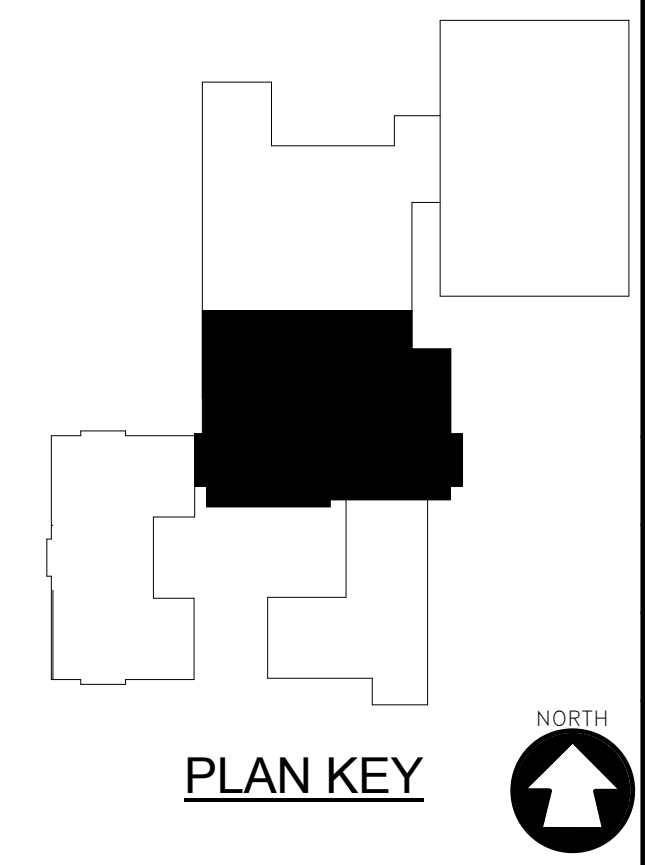


McMahon provides this drawing and data, regardless of form; instruments of service. All rights including copyrights are retained by McMahon. The client and recipient agrees to the best extent permitted by law indemnify and hold McMahon harmless for any reuse of or changes made to the original drawing or data without prior written consent by McMahon.

[illegible]

DESIGNED R.JW		DRAWN MAL	
PROJECT NO. O0002-61600160			
DATE MARCH 3, 2017			
SHEET NO. EP238			

DESIGNED RJW	DRAWN MAL
PROJECT NO. O0002-61600160	
DATE MARCH 3, 2017	
SHEET NO. EP238	

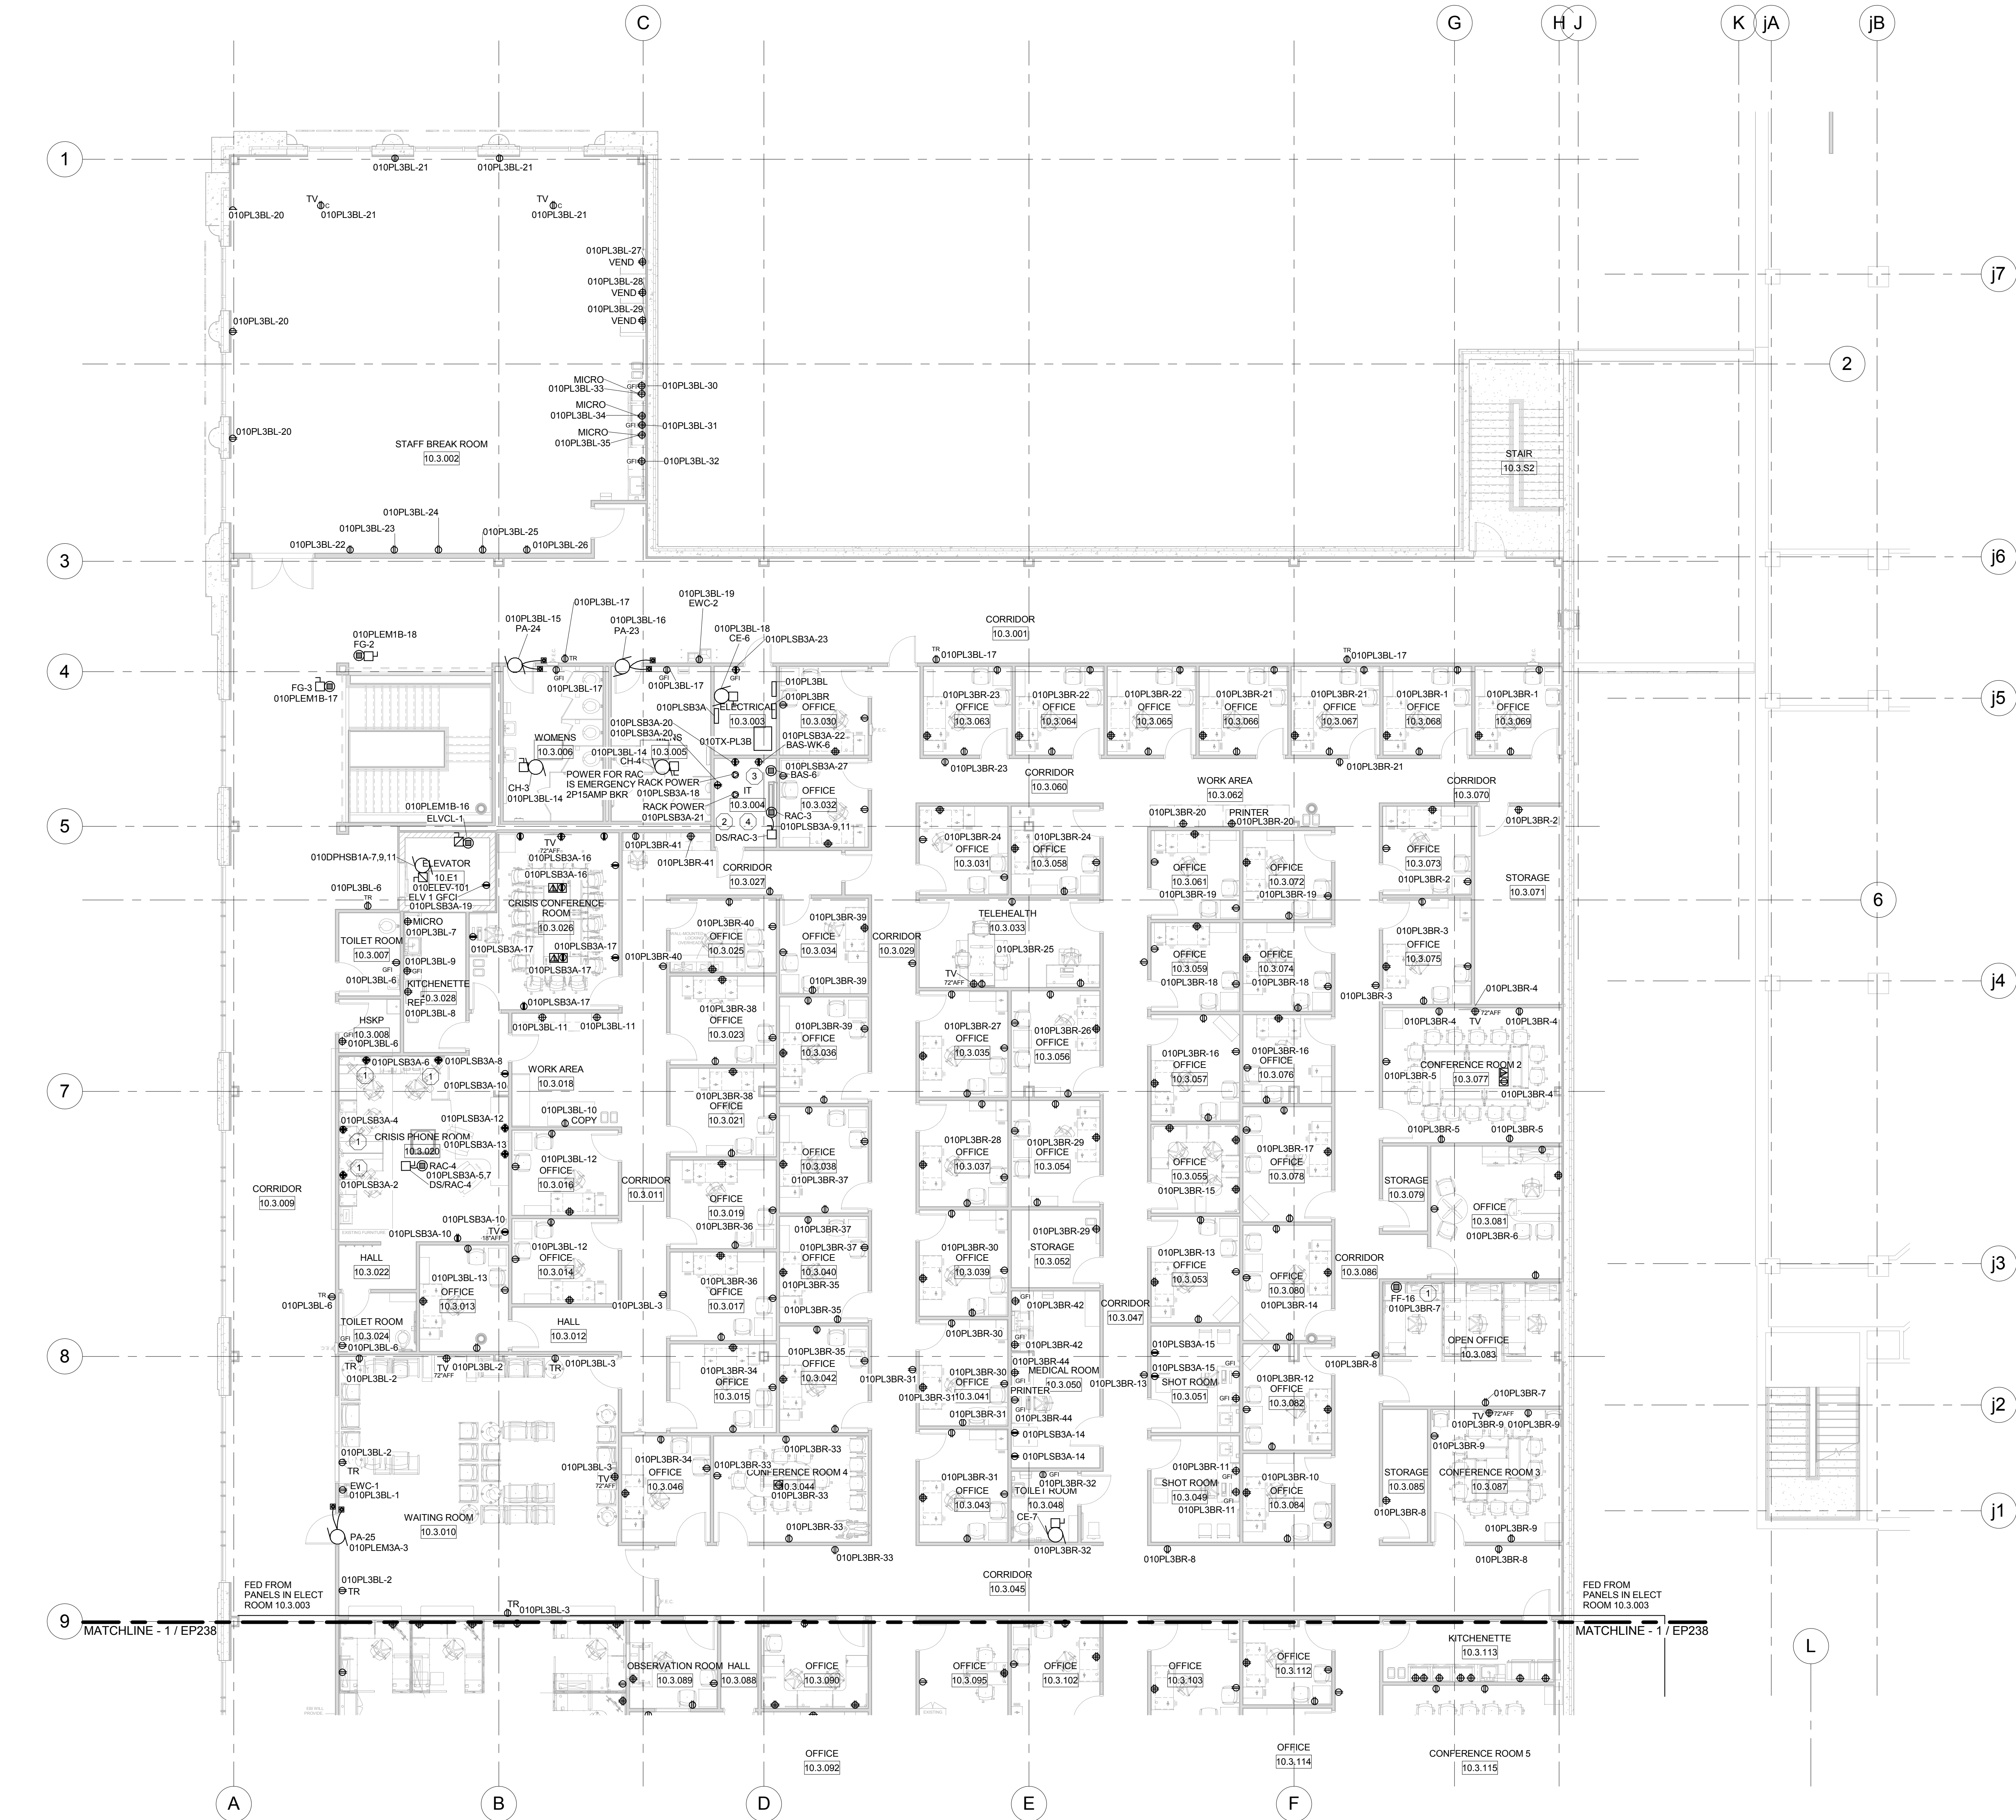

1 LEVEL 820.00 POWER PLAN-OCAC NORTH
Scale: 1/8" = 1'-0"

GENERAL NOTES:

- A. RECEPTACLES LOCATED WITHIN 6' OF SINK AND NOT READILY ACCESSIBLE SHALL BE FED WITH 20AMP GFCI BREAKER FROM LOCAL PANEL.
- B. COORDINATE FLOOR BOX LOCATION PRIOR TO INSTALLATION.
- C. COORDINATE RECEPTACLE PLACEMENT WITH OFFICE FURNITURE LAYOUTS.
- D. VERIFY MOUNTING HEIGHT WITH OWNER PRIOR TO INSTALLATION FOR ANY WALL MOUNTED MONITOR.
- E. ALL RECEPTACLES WHICH ARE CONNECTED TO AN EMERGENCY (EM AND/OR SB) SYSTEM BRANCH CIRCUIT SHALL BE RED IN COLOR. PROVIDE MATCHING RED COVER PLATE FOR EACH DEVICE.

PLAN NOTES:

1. PROVIDED HARDWIRE FURNITURE CONNECTION TO WORKSTATION FROM WALL LOCATION.
2. COORDINATE RECEPTACLE PLACEMENT WITH FINAL EQUIPMENT LOCATIONS.
3. PROVIDE AN EMERGENCY POWER CONNECTION TO (BAS) BUILDING AUTOMATION SYSTEM CONTROL PANEL AND WORK STATION RECEPTACLE (BAS-WK) PANEL PROVIDED AND INSTALLED BY OTHERS. VERIFY FINAL LOCATION WITH CONTRACTOR INSTALLING (BAS) SYSTEM PRIOR TO CONDUIT INSTALLATION. CURRENT LOCATION ACCOUNTS FOR PANEL SPACE, AND CONTROL PANEL CIRCUIT.
4. PROVIDE 120VAC POWER CONNECTIONS TO THE FOLLOWING SECURITY, FIRE ALARM, AND SYSTEMS EQUIPMENT: (3) FA NAC'S PER FLOOR USING (1) 120VAC 15AMP CIRCUIT, (2) TRANSPONDERS FOR THE DURESS SYSTEM, EACH USING (1) 120VAC 15AMP CIRCUIT, AND (3) POWER SUPPLIES FOR THE ACCESS CONTROL SYSTEM, EACH WITH 120VAC 15AMP CIRCUITS. (1) PAGING AMP PER FLOOR THAT WILL REQUIRE A 120V CIRCUIT TO A POWER SUPPLY PLUG IN TRANSFORMER WHICH CAN BE SUPPLIED FROM A RECEPTACLE. VERIFY SYSTEMS, SECURITY, AND FIRE ALARM DRAWINGS, AND PROVIDERS WHERE CIRCUITING WILL ORIGINATE FROM (NORMAL OR EMERGENCY SOURCES). PROVIDE BREAKERS AND BREAKER LOOKS AS SPECIFIED PER EQUIPMENT BEING INSTALLED. INDICATE ON AS-BUILT DRAWINGS AND PANEL SCHEDULES WHERE CIRCUITING FOR EQUIPMENT IS TERMINATED.

MCMANON
ENGINEERS ARCHITECTS
1000 N. WALNUT ST. SUITE 100
MILWAUKEE, WI 53233
Tel: (414) 751-4200 Fax: (414) 751-4284
www.mcmahon.com

REVISION

DATE

NO.

ALTERATION / ADDITION
OUTAGAME COUNTY ADMINISTRATION CENTER
S. WALNUT & W. 8TH, APPLETON WI 54911
LEVEL 820.00 POWER PLAN-OCAC NORTH

DESIGNED

R.J.W.

DRAWN

MAL

PROJECT NO.


00002-61600160

DATE

MARCH 3, 2017


SHEET NO.

EP239

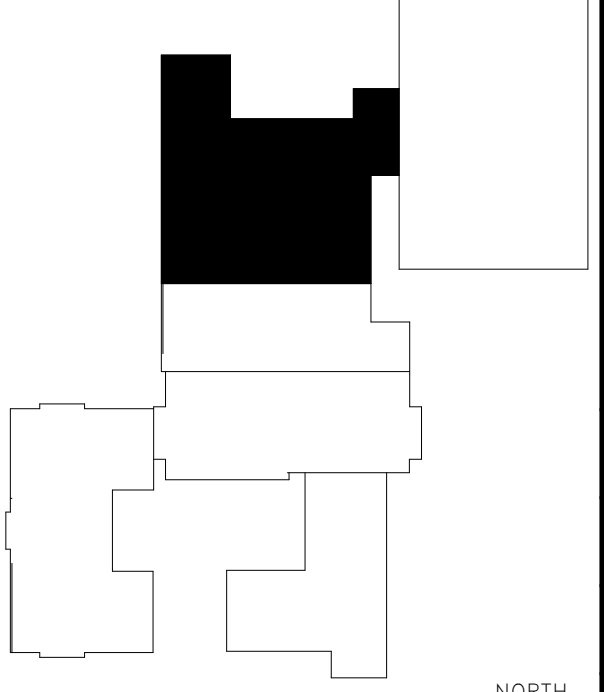

PLAN KEY




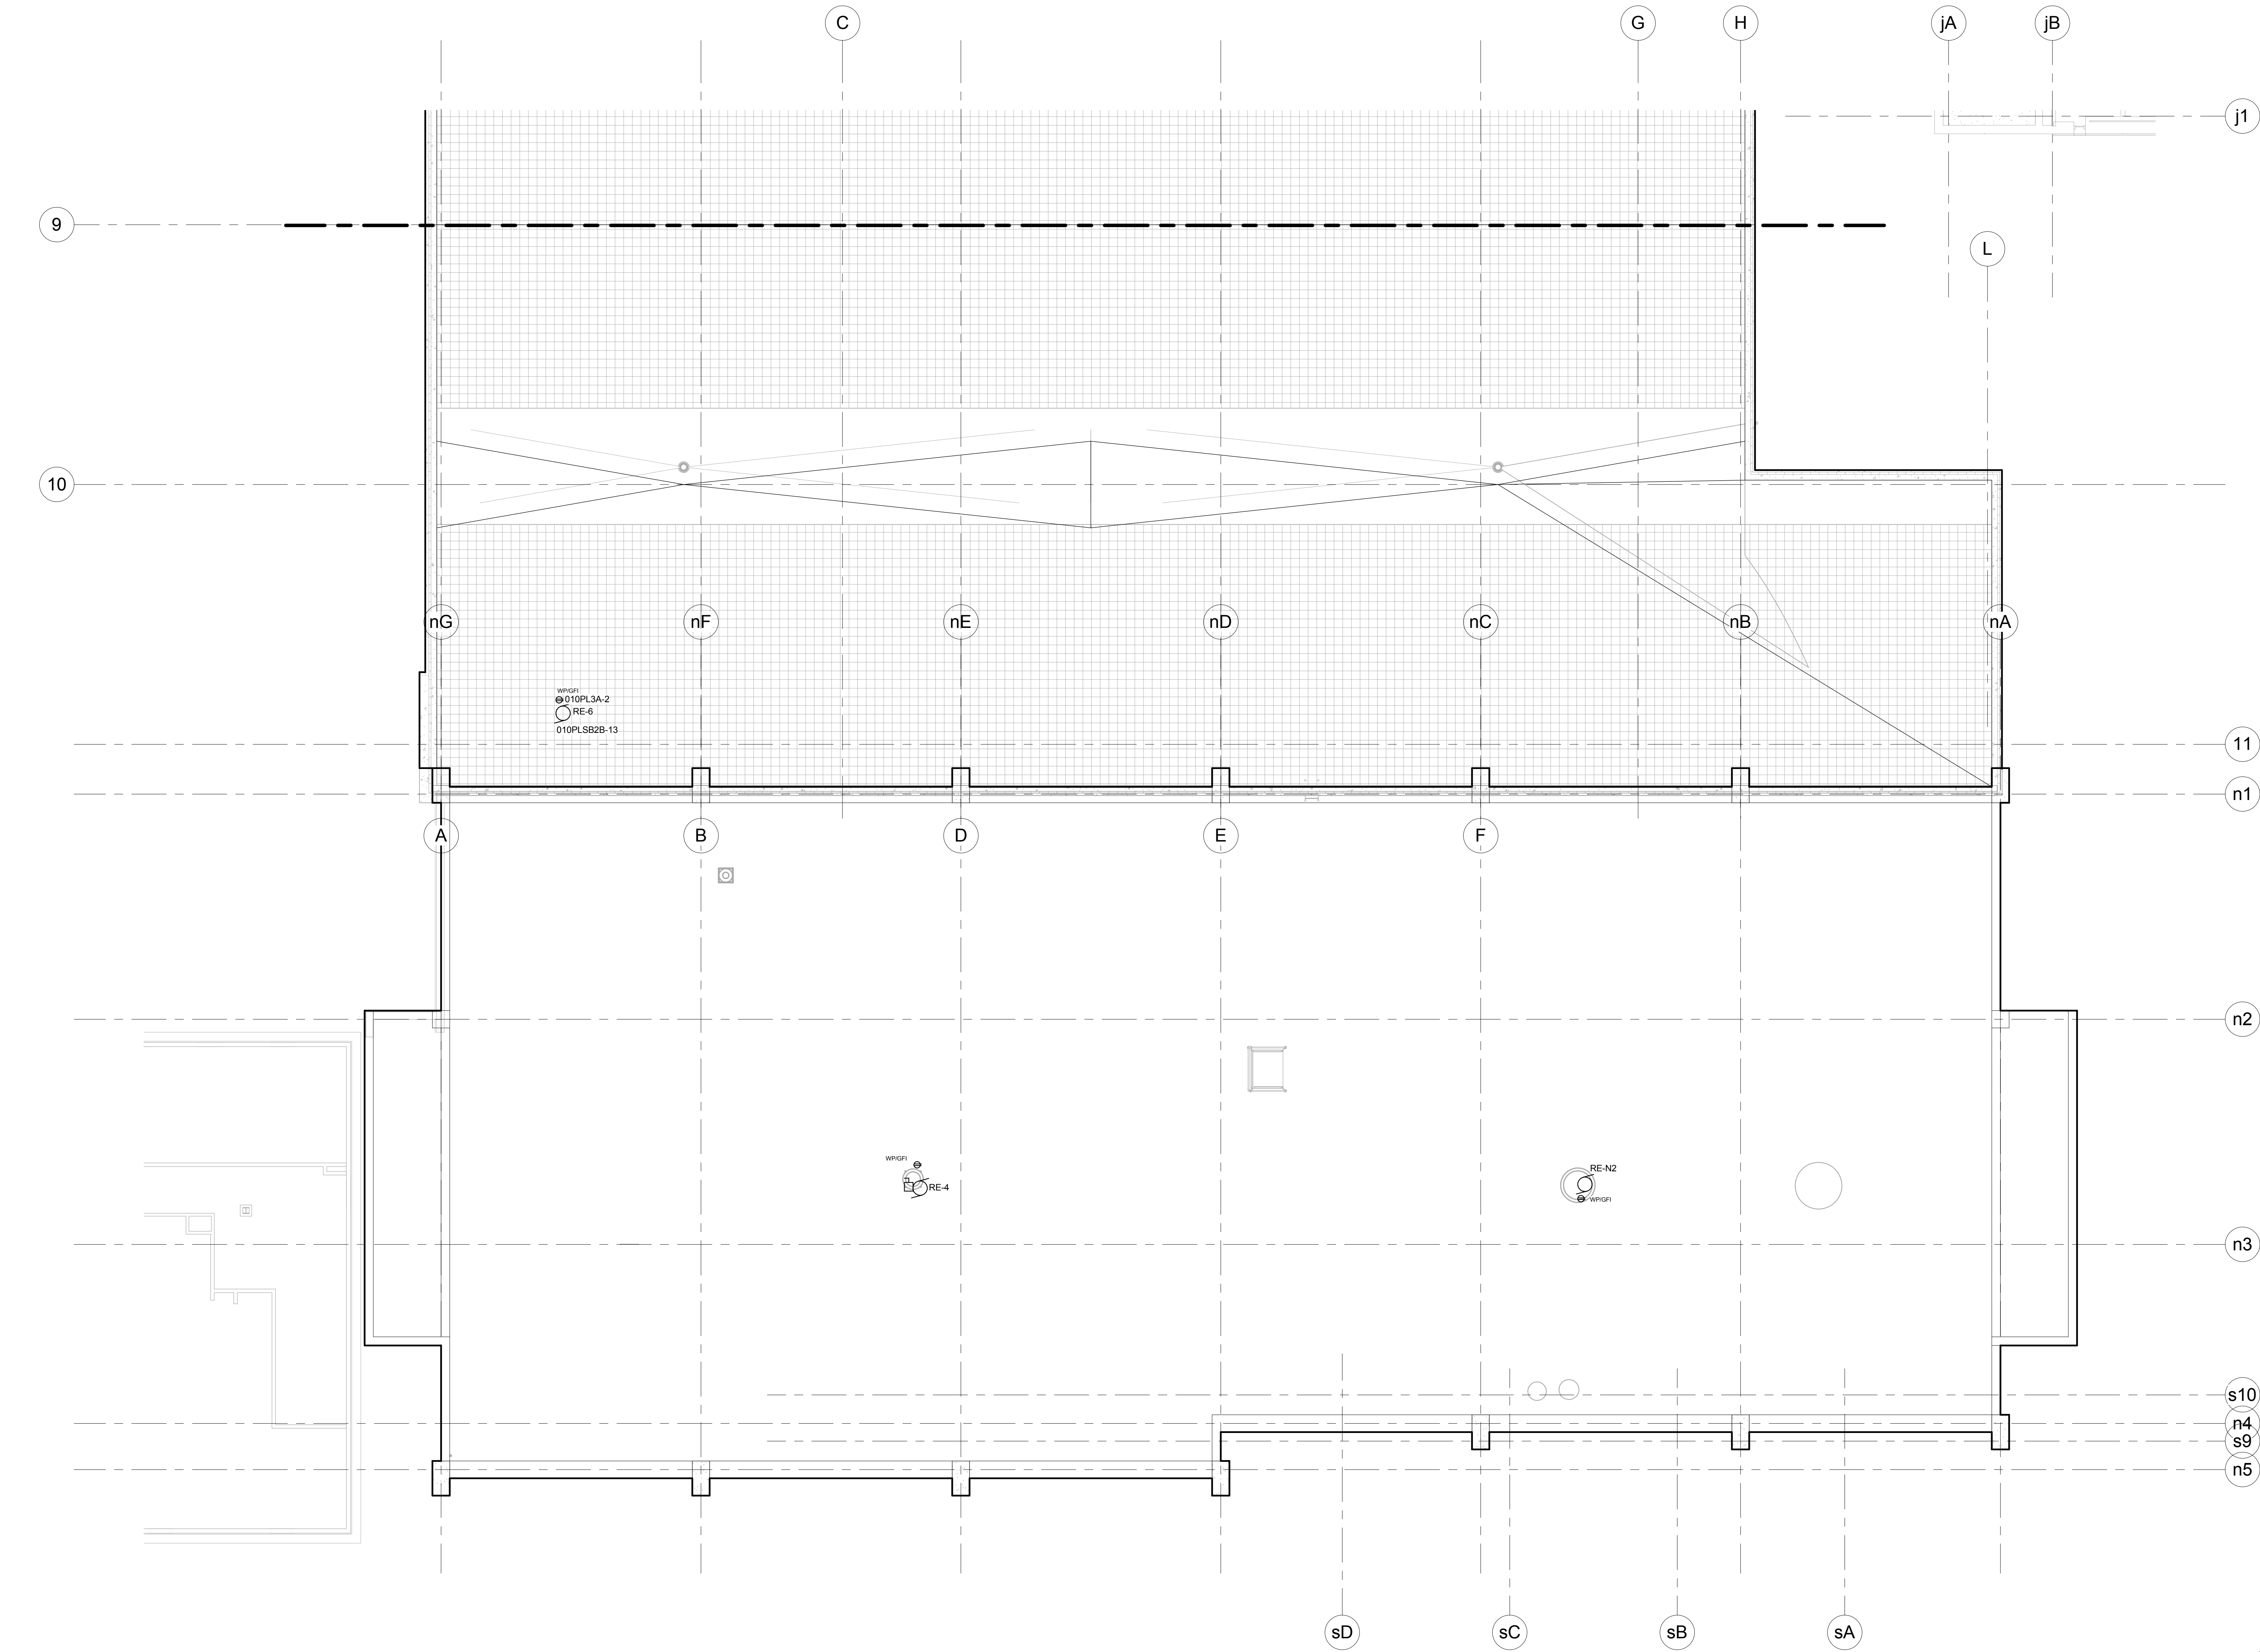

GENERAL NOTES:
A. EXTERIOR RECEPTACLES WHEN INDICATED OUTDOORS SHALL BE GFCI, AND WEATHER RESISTANT WITH METAL HEAVY DUTY IN-USE COVERS.


1 ROOF LEVEL POWER PLAN-HHS NORTH/OCAC SOUTH
Scale: 1/8" = 1'-0"

NO.	DATE	REVISION

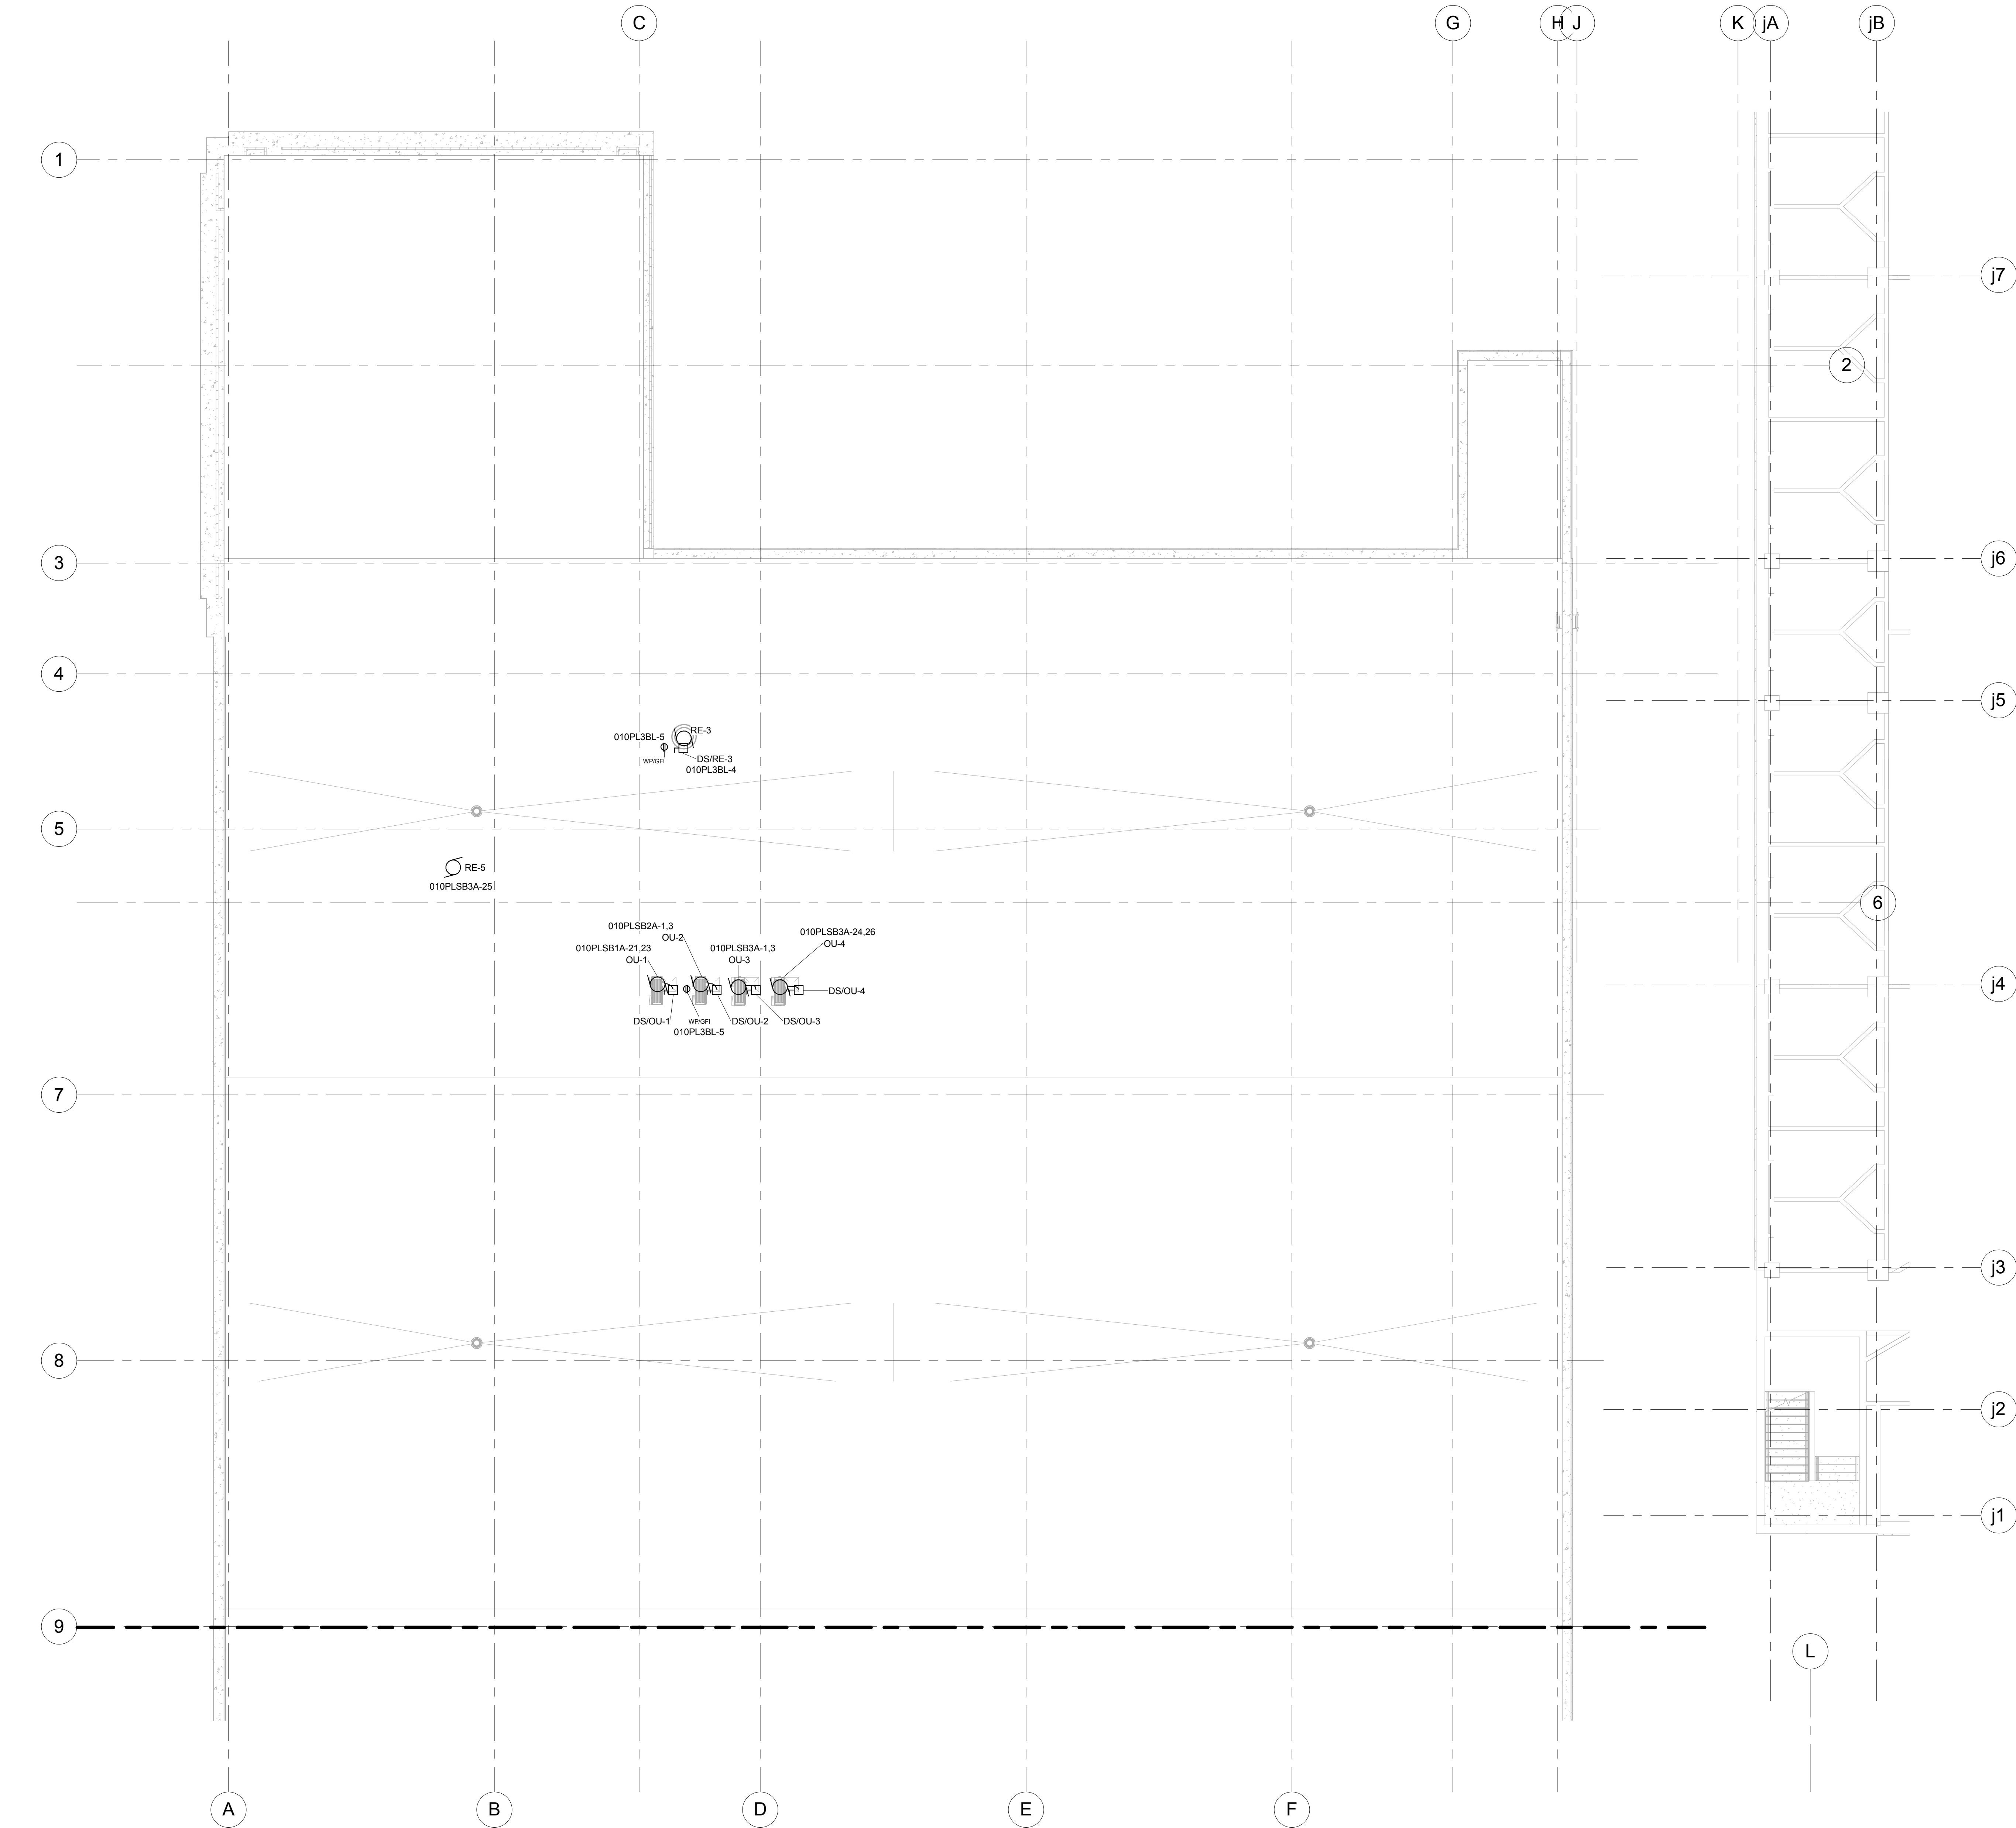

1 ROOF LEVEL POWER PLAN-OCAC NORTH
Scale: 1/8" = 1'-0"

GENERAL NOTES:
A. EXTERIOR RECEPTACLES WHEN INDICATED OUTDOORS SHALL BE GFCI AND WEATHER RESISTANT WITH METAL HEAVY DUTY IN-USE COVERS.
B. WHERE FLEXIBLE CONNECTIONS ARE REQUIRED WHEN LOCATED OUTDOORS FROM DISCONNECTS OR VFDs TO MOTORS SHALL BE FLEXIBLE, NON-CORROSIVE, AND UV RESISTANT.

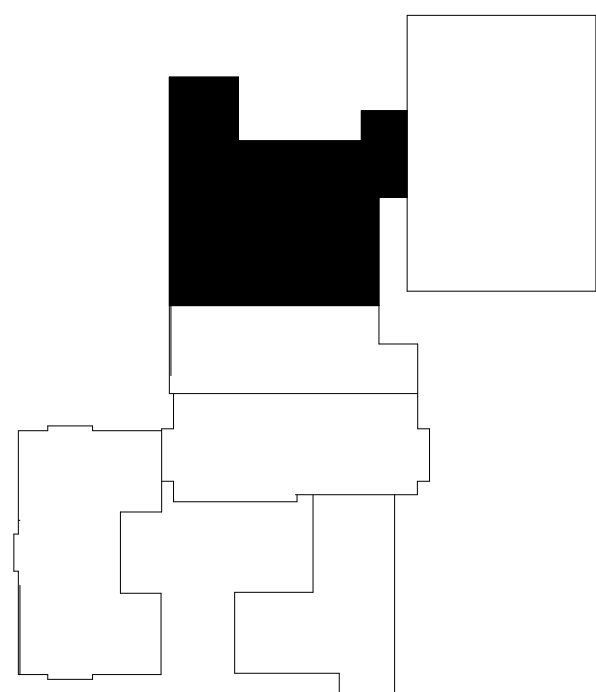

2/28/2017 4:01:23 PM

C:\Revel Projects\16_1108 OCAC_Elec_mahon.dwg

HVAC EQUIPMENT SCHEDULE										
CALLOUT	EQUIPMENT DESCRIPTION	COUNT	VOLTAGE	POLES	LOAD (KVA)	HORSEPOWER	PANEL	CIRCUIT	LOCATION	NOTES
AHU-10-1-1	AIR HANDLING UNIT	1	480 V	3	17.459	15	010MSB1A	9	MECHANICAL 10.1.145	PROVIDE VFD RATED WIRING TYPE XHHW-2 OR GREATER
AHU-10-1-2	AIR HANDLING UNIT	1	480 V	3	17.459	15	010MSB1A	8	MECHANICAL 10.1.145	PROVIDE VFD RATED WIRING TYPE XHHW-2 OR GREATER
AHU-10-2-1	AIR HANDLING UNIT	1	480 V	3	17.459	15	010DPH2A	7,9,11	MECHANICAL 10.2.084	PROVIDE VFD RATED WIRING TYPE XHHW-2 OR GREATER
AHU-10-2-2	AIR HANDLING UNIT	1	480 V	3	17.459	15	010DPH2A	8,10,12	MECHANICAL 10.2.084	PROVIDE VFD RATED WIRING TYPE XHHW-2 OR GREATER
AHU-10-3-1	AIR HANDLING UNIT	1	480 V	3	17.459	15	010DPH3A	7,9,11	MECHANICAL 10.3.123	PROVIDE VFD RATED WIRING TYPE XHHW-2 OR GREATER
AHU-10-3-2	AIR HANDLING UNIT	1	480 V	3	17.459	15	010DPH3A	8,10,12	MECHANICAL 10.3.123	PROVIDE VFD RATED WIRING TYPE XHHW-2 OR GREATER
AHU-N2	AIR HANDLING UNIT	1	480 V	3	11.639	10			MECHANICAL 03.3.174	PROVIDE NEW CONDUIT, WIRING AND ALL TERMINATIONS FROM AND EXISTING PANEL LOCATION FOR REPLACEMENT OF UNIT. BREAKER SERVING UNIT SHALL BE SIZED AT MINIMUM OF 25AMPS. SEE HVAC DRAWINGS H001 FOR ADDITIONAL INFORMATION.
BAS-1	BUILDING AUTOMATION SYSTEM CONTROL PANEL	1	120 V	1	1.92		010PLSB2B	5	MECHANICAL 10.1.145	PROVIDE EMERGENCY POWER CONNECTION TO SUPPLIED AND INSTALLED CONTROL PANEL
BAS-2	BUILDING AUTOMATION SYSTEM CONTROL PANEL	1	120 V	1	1.92		010PLSB2B	7	MECHANICAL 10.2.084	PROVIDE EMERGENCY POWER CONNECTION TO SUPPLIED AND INSTALLED CONTROL PANEL
BAS-3	BUILDING AUTOMATION SYSTEM CONTROL PANEL	1	120 V	1	1.92		010PLSB2B	15	MECHANICAL 10.1.145	PROVIDE EMERGENCY POWER CONNECTION TO SUPPLIED AND INSTALLED CONTROL PANEL
BAS-4	BUILDING AUTOMATION SYSTEM CONTROL PANEL	1	120 V	1	1.5		010PLSB1A	17	IT 10.1.034	PROVIDE EMERGENCY POWER CONNECTION TO SUPPLIED AND INSTALLED CONTROL PANEL
BAS-5	BUILDING AUTOMATION SYSTEM CONTROL PANEL	1	120 V	1	1.92		010PLSB2A	5	IT 10.2.013	PROVIDE EMERGENCY POWER CONNECTION TO SUPPLIED AND INSTALLED CONTROL PANEL
BAS-6	BUILDING AUTOMATION SYSTEM CONTROL PANEL	1	120 V	1	1.92		010PLSB3A	27	IT 10.3.004	PROVIDE EMERGENCY POWER CONNECTION TO SUPPLIED AND INSTALLED CONTROL PANEL
BAS-WK-1	BUILDING AUTOMATION SYSTEM WORKSTATION	1	120 V	1	0.4		010PLSB2B	6	MECHANICAL 10.1.145	COORDINATE FINAL RECEPTACLE LOCATION AND MOUNTING HEIGHT
BAS-WK-2	BUILDING AUTOMATION SYSTEM WORKSTATION	1	120 V	1	0.4		010PLSB2B	8	MECHANICAL 10.2.084	COORDINATE FINAL RECEPTACLE LOCATION AND MOUNTING HEIGHT
BAS-WK-3	BUILDING AUTOMATION SYSTEM WORKSTATION	1	120 V	1	0.4		010PLSB2B	12	MECHANICAL 10.2.084	COORDINATE FINAL RECEPTACLE LOCATION AND MOUNTING HEIGHT
BAS-WK-4	BUILDING AUTOMATION SYSTEM WORKSTATION	1	120 V	1	0.4		010PLSB1A	18	IT 10.1.034	COORDINATE FINAL RECEPTACLE LOCATION AND MOUNTING HEIGHT
BAS-WK-5	BUILDING AUTOMATION SYSTEM WORKSTATION	1	120 V	1	3.4		010PLSB2A	9	IT 10.2.013	COORDINATE FINAL RECEPTACLE LOCATION AND MOUNTING HEIGHT
BAS-WK-6	BUILDING AUTOMATION SYSTEM WORKSTATION	1	120 V	1	0.4		010PLSB3A	22	IT 10.3.004	COORDINATE FINAL RECEPTACLE LOCATION AND MOUNTING HEIGHT
CE-1	CEILING EXHAUST FAN	1	120 V	1	0.4	FRAC	PNL 3B	2	TOILET ROOM 10.2.054	PROVIDE LOCAL MOTOR RATED DISCONNECTING MEANS
CE-2	CEILING EXHAUST FAN	1	120 V	1	0.4	FRAC	PNL 3B	2	TOILET ROOM 03.2.109	PROVIDE LOCAL MOTOR RATED DISCONNECTING MEANS
CE-3	CEILING EXHAUST FAN	1	120 V	1	0.4	FRAC	PNL 4A	3	TOILET ROOM 03.3.145	PROVIDE LOCAL MOTOR RATED DISCONNECTING MEANS
CE-4	CEILING EXHAUST FAN	1	120 V	1	0.4	FRAC	010PL1BL	33	ELECTRICAL 10.1.025	PROVIDE LOCAL MOTOR RATED DISCONNECTING MEANS
CE-5	CEILING EXHAUST FAN	1	120 V	1	0.4	FRAC	010PL2B	50	ELECT. 10.2.012	PROVIDE LOCAL MOTOR RATED DISCONNECTING MEANS
CE-6	CEILING EXHAUST FAN	1	120 V	1	0.4	FRAC	010PL3BL	18	ELECTRICAL 10.3.003	PROVIDE LOCAL MOTOR RATED DISCONNECTING MEANS
CE-7	CEILING EXHAUST FAN	1	120 V	1	0.4	FRAC	010PL3BR	32	TOILET ROOM 10.3.048	PROVIDE LOCAL MOTOR RATED DISCONNECTING MEANS
CH-1	CABINET HEATER	1	120 V	1	0.2	.06	010PL1BL	30	WOMENS 10.1.027	PROVIDE LOCAL MOTOR RATED DISCONNECTING MEANS
CH-2	CABINET HEATER	1	120 V	1	0.2	.06	010PL1BL	30	MENS 10.1.026	PROVIDE LOCAL MOTOR RATED DISCONNECTING MEANS
CH-3	CABINET HEATER	1	120 V	1	0.2	.06	010PL3BL	14	WOMENS 10.3.006	PROVIDE LOCAL MOTOR RATED DISCONNECTING MEANS
CH-4	CABINET HEATER	1	120 V	1	0.2	.06	010PL3BL	14	MENS 10.3.005	PROVIDE LOCAL MOTOR RATED DISCONNECTING MEANS
CH-5	CABINET HEATER	1	120 V	1	0.1	.1	010PL1S2	27	STAIR 10.1.S2	PROVIDE LOCAL MOTOR RATED DISCONNECTING MEANS
CH-6	CABINET HEATER	1	120 V	1	0.1	.1	010PL1BL	27	PEDESTRIAN WALKWAY 10.1.024	PROVIDE LOCAL MOTOR RATED DISCONNECTING MEANS
CT-1	COOLING TOWER FAN 1	1	480 V	3	43.231	40	GNHM	1,3,5	MECHANICAL 10.1.145	CT-1 FED FROM VFD-10
CT-2	COOLING TOWER FAN 2	1	480 V	3	43.231	40	GNHM	2,4,6	MECHANICAL 10.1.145	CT-2 FED FROM VFD-11
DS-1	DESTRATIFICATION FAN #2	1	120 V	1	0.3	FRAC	010PL2B	49	OCAC NORTH 805.00	PROVIDE FAN RATED BOX. LOCAL DISCONNECTING MEANS NEAR UNIT. VERIFY ADDITIONAL CONTROL MEANS WITH HVAC CONTRACTOR, PROVIDE 120VAC AS REQUIRED FOR FAN CONTROL.
DS-2	DESTRATIFICATION FAN #1	1	120 V	1	0.3	FRAC	010PL2B	44	OCAC NORTH 805.00	PROVIDE FAN RATED BOX. LOCAL DISCONNECTING MEANS NEAR UNIT. VERIFY ADDITIONAL CONTROL MEANS WITH HVAC CONTRACTOR, PROVIDE 120VAC AS REQUIRED FOR FAN CONTROL.
DS-3	DESTRATIFICATION FAN #3	1	120 V	1	0.3	FRAC	010PL2B	44	OCAC NORTH 805.00	PROVIDE FAN RATED BOX. LOCAL DISCONNECTING MEANS NEAR UNIT. VERIFY ADDITIONAL CONTROL MEANS WITH HVAC CONTRACTOR, PROVIDE 120VAC AS REQUIRED FOR FAN CONTROL.
EF-12	EXHAUST FAN BOILER ROOM	1	480 V	3	2.827	2			MECHANICAL G061	EXISTING REPLACED WITH NEW, PROVIDE CONDUIT, WIRING FROM NEW VFD LOCATION. PROVIDE VFD RATED CONDUCTORS FROM SECONDARY SIDE OF VFD.
FPV-1	FAN POWERED VAV BOX	1	277 V	1	0.305	1/8			NEAR STORAGE 04.0.048	UTILIZE EXISTING MOTOR DISCONNECTING MEANS FROM PREVIOUS VAV BOX MOTOR
FPV-2	FAN POWERED VAV BOX	1	277 V	1	0.475	1/4			NEAR STORAGE 04.0.048	UTILIZE EXISTING MOTOR DISCONNECTING MEANS FROM PREVIOUS VAV BOX MOTOR
FPV-3	FAN POWERED VAV BOX	1	277 V	1	0.475	1/4			STORAGE 04.0.048	UTILIZE EXISTING MOTOR DISCONNECTING MEANS FROM PREVIOUS VAV BOX MOTOR
FPV-4	FAN POWERED VAV BOX	1	277 V	1	0.305	1/8			EMERGENCY OPERATION CENTER 04.0.007a	UTILIZE EXISTING MOTOR DISCONNECTING MEANS FROM PREVIOUS VAV BOX MOTOR
FPV-5	FAN POWERED VAV BOX	1	277 V	1	0.305	1/8			OPEN OFFICE 04.0.005	UTILIZE EXISTING MOTOR DISCONNECTING MEANS FROM PREVIOUS VAV BOX MOTOR
FPV-6	FAN POWERED VAV BOX	1	277 V	1	0.305	1/8			OPEN OFFICE 04.0.005	UTILIZE EXISTING MOTOR DISCONNECTING MEANS FROM PREVIOUS VAV BOX MOTOR
FPV-7	FAN POWERED VAV BOX	1	277 V	1	0.475	1/4			CLASSROOM/ TRAINING 04.0.007b	UTILIZE EXISTING MOTOR DISCONNECTING MEANS FROM PREVIOUS VAV BOX MOTOR
FPV-8	FAN POWERED VAV BOX	1	277 V	1	0.305	1/8			CONFERENCE ROOM 04.0.012	UTILIZE EXISTING MOTOR DISCONNECTING MEANS FROM PREVIOUS VAV BOX MOTOR
FPV-9	FAN POWERED VAV BOX	1	277 V	1	0.305	1/8			CORRIDOR 04.0.017	UTILIZE EXISTING MOTOR DISCONNECTING MEANS FROM PREVIOUS VAV BOX MOTOR
FPV-10	FAN POWERED VAV BOX	1	277 V	1	0.305	1/8			STORAGE 04.0.013	UTILIZE EXISTING MOTOR DISCONNECTING MEANS FROM PREVIOUS VAV BOX MOTOR
FPV-11	FAN POWERED VAV BOX	1	277 V	1	0.305	1/8			NEAR WAITING 04.1.001	UTILIZE EXISTING MOTOR DISCONNECTING MEANS FROM PREVIOUS VAV BOX MOTOR
FPV-12	FAN POWERED VAV BOX	1	277 V	1	0.305	1/8			CORRIDOR 04.1.007	UTILIZE EXISTING MOTOR DISCONNECTING MEANS FROM PREVIOUS VAV BOX MOTOR
FPV-13	FAN POWERED VAV BOX	1	277 V	1	0.305	1/8			WAITING 04.1.001	UTILIZE EXISTING MOTOR DISCONNECTING MEANS FROM PREVIOUS VAV BOX MOTOR
FPV-14	FAN POWERED VAV BOX	1	277 V	1	0.305	1/8			CONFERENCE ROOM 04.1.005	UTILIZE EXISTING MOTOR DISCONNECTING MEANS FROM PREVIOUS VAV BOX MOTOR
FPV-15	FAN POWERED VAV BOX	1	277 V	1	0.305	1/8			OPEN OFFICE 04.1.008	UTILIZE EXISTING MOTOR DISCONNECTING MEANS FROM PREVIOUS VAV BOX MOTOR
FPV-16	FAN POWERED VAV BOX	1	277 V	1	0.475	1/4			OPEN OFFICE 04.1.008	UTILIZE EXISTING MOTOR DISCONNECTING MEANS FROM PREVIOUS VAV BOX MOTOR
FPV-17	FAN POWERED VAV BOX	1	277 V	1	0.305	1/8			CONFERENCE ROOM 04.1.019	UTILIZE EXISTING MOTOR DISCONNECTING MEANS FROM PREVIOUS VAV BOX MOTOR
FPV-18	FAN POWERED VAV BOX	1	277 V	1	0.305	1/8			OPEN OFFICE 04.1.008	UTILIZE EXISTING MOTOR DISCONNECTING MEANS FROM PREVIOUS VAV BOX MOTOR
FPV-19	FAN POWERED VAV BOX	1	277 V	1	0.305	1/8			OPEN OFFICE 04.1.008	UTILIZE EXISTING MOTOR DISCONNECTING MEANS FROM PREVIOUS VAV BOX MOTOR
FPV-20	FAN POWERED VAV BOX	1	277 V	1	0.305	1/8			CORRIDOR 04.1.025	UTILIZE EXISTING MOTOR DISCONNECTING MEANS FROM PREVIOUS VAV BOX MOTOR
FPV-21	FAN POWERED VAV BOX	1	277 V	1	0.305	1/8			CORRIDOR 04.1.025	UTILIZE EXISTING MOTOR DISCONNECTING MEANS FROM PREVIOUS VAV BOX MOTOR
FPV-22	FAN POWERED VAV BOX	1	277 V	1	0.475	1/4			OPEN OFFICE 04.1.036	UTILIZE EXISTING MOTOR DISCONNECTING MEANS FROM PREVIOUS VAV BOX MOTOR
FPV-23	FAN POWERED VAV BOX	1	277 V	1	0.305	1/8			CONFERENCE ROOM 04.1.041	UTILIZE EXISTING MOTOR DISCONNECTING MEANS FROM PREVIOUS VAV BOX MOTOR
FPV-24	FAN POWERED VAV BOX	1	277 V	1	0.305	1/8			OFFICE 04.1.043	UTILIZE EXISTING MOTOR DISCONNECTING MEANS FROM PREVIOUS VAV BOX MOTOR
FPV-25	FAN POWERED VAV BOX	1	277 V	1	0.305	1/8			CORRIDOR 04.1.025	UTILIZE EXISTING MOTOR DISCONNECTING MEANS FROM PREVIOUS VAV BOX MOTOR
FPV-26	FAN POWERED VAV BOX	1	277 V	1	0.305	1/8			VISITATION 04.1.045	UTILIZE EXISTING MOTOR DISCONNECTING MEANS FROM PREVIOUS VAV BOX MOTOR
FPV-27	FAN POWERED VAV BOX	1	277 V	1	1.22	3/4			NEAR COURTROOM 04.2.001	PROVIDE NEW 30AMP MOTOR RATED DISCONNECTING MEANS WITH OVERLOADS, LOCATED NEAR UNIT.
FPV-28	FAN POWERED VAV BOX	1	277 V	1	0.305	1/8			WORK ROOM 04.1.017	PROVIDE MOTOR RATED DISCONNECTING MEANS LOCATED NEAR UNIT.
FPV-29	FAN POWERED VAV BOX	1	277 V	1	0.305	1/8			CORRIDOR 04.1.025	UTILIZE EXISTING MOTOR DISCONNECTING MEANS FROM PREVIOUS VAV BOX MOTOR
IP-1	EXISTING BOILER B-1	1	480 V	3	6.318	5			MECHANICAL G061	FED FROM VFD 21
IP-2	EXISTING BOILER B-2	1	480 V	3	6.318	5			MECHANICAL G061	FED FROM VFD 22
IP-3	EXISTING BOILER B-3	1	480 V	3	3.991	3			MECHANICAL G061	FED FROM VFD 23
IP-4	IN-FLOOR RADIANT HEAT PUMP	1	120 V	1	0.696	1/4	010PL1BL	8	EXCHANGE ROOM 10.1.004	MOUNTED ABOVE CEILING, PROVIDE LOCAL MOTOR RATED DISCONNECTING MEANS

GENERAL NOTES:

A. MECHANICAL CONTRACTOR SHALL FURNISH ALL STARTING EQUIPMENT, INCLUDING SWITCHES, RELAYS, ETC AND SHALL TURN THOSE OVER TO THE ELECTRICAL CONTRACTOR FOR INSTALLATION AND WIRING (POWER).
I. CONTROL WIRING SHALL BE BY THE TEMPERATURE CONTROLS SUBCONTRACTOR.

B. ELECTRICAL CONTRACTOR SHALL FURNISH AND INSTALL ALL MOTOR RATED DISCONNECTS WITH OVERLOAD PROTECTION, FUSED AND/OR CIRCUIT BREAKER DISCONNECTS, EXCEPT AS INDICATED OTHERWISE.

C. VARIABLE FREQUENCY DRIVES ARE SPECIFIED TO INCLUDE DOOR INTERLOCKED MAIN CIRCUIT BREAKER OR FUSED DISCONNECT FOR DRIVE.

GENERAL NOTES CONT:

D. VARIABLE FREQUENCY DRIVES ARE TO BE SET IN PLACE BY THE MECHANICAL CONTRACTOR AND WIRED (POWER) BY THE ELECTRICAL CONTRACTOR.
I. CONTROL WIRING SHALL BE BY THE TEMPERATURE CONTROLS SUBCONTRACTOR.

E. COMPLETE BUILDING AUTOMATION SYSTEM IS BY MECHANICAL CONTRACTOR.

I. THRU BAS SUBCONTRACTOR
1. INCLUDES ALL WIRING, OTHER THAN POWER WIRING FROM PANEL SOURCE TO STARTER AND/OR VFD AND TO MOTOR.
2. BRANCH CIRCUIT WIRING FROM PANEL SOURCE TO BAS PANEL AND BAS PERSONAL COMPUTER WORKSTATIONS) PROVIDED BY ELECTRICAL CONTRACTOR. BAS IS TO REFER TO ELECTRICAL DRAWINGS AND COORDINATE WITH THE ELECTRICAL CONTRACTOR FOR PLACEMENT OF BAS CONTROLLER AND WORKSTATION LOCATIONS.

HVAC EQUIPMENT SCHEDULE CONT.

CALLOUT	EQUIPMENT DESCRIPTION	COUNT	VOLTAGE	POLES	LOAD (KVA)	HORSEPOWER	PANEL	CIRCUIT	LOCATION	NOTES
OU-1	OUTDOOR CONDENSING UNIT	1	208 V	2	3.744		010PLSB1A	21,23	OCAC NORTH ROOFTOP	30AMP MOCPP, FED FROM EMERGENCY PANEL, SEE HVAC H001 FOR ADDITIONAL INFORMATION
OU-2	OUTDOOR CONDENSING UNIT	1	208 V	2	3.744		010PLSB2A	1,3	OCAC NORTH ROOFTOP	30AMP MOCPP, FED FROM EMERGENCY PANEL, SEE HVAC H001 FOR ADDITIONAL INFORMATION
OU-3	OUTDOOR CONDENSING UNIT	1	208 V	2	3.744		010PLSB3A	1,3	OCAC NORTH ROOFTOP	30AMP MOCPP, FED FROM EMERGENCY PANEL, SEE HVAC H001 FOR ADDITIONAL INFORMATION
OU-4	OUTDOOR CONDENSING UNIT	1	208 V	2	3.744		010PLSB3A	24,26	OCAC NORTH ROOFTOP	30AMP MOCPP, FED FROM EMERGENCY PANEL, SEE HVAC H001 FOR ADDITIONAL INFORMATION
P-1	CHILLED WATER LEAD	1	480 V	3	54.038	50	GNHM	7,9,11	MECHANICAL G061	FED FROM VFD-12
P-2	CHILLED WATER LAG	1	480 V	3	54.038	50	GNHM	8,10,12	MECHANICAL G061	FED FROM VFD-13
P-3	CHILLED WATER STAND-BY	1	480 V	3	54.038	50	GNHM	13,15,17	MECHANICAL G061	FED FROM VFD-14
P-4	CONDENSER WATER LEAD	1	480 V	3	43.231	40	GNHM	14,16,18	MECHANICAL 10.1.145	FED FROM VFD-15
P-5	CONDENSER WATER LAG	1	480 V	3	43.231	40	GNHM	19,21,23	MECHANICAL 10.1.145	FED FROM VFD-16
P-6	CONDENSER WATER STAND-BY	1	480 V	3	43.231	40	GNHM	20,22,24	MECHANICAL 10.1.145	FED FROM VFD-17
P-7	HOT WATER LEAD	1	480 V	3	33.254	30			MECHANICAL G061	FED FROM VFD-18
P-8	HOT WATER LAG	1	480 V	3	33.254	30			MECHANICAL G061	FED FROM VFD-19
P-9	HOT WATER STAND-BY	1	480 V	3	33.254	30			MECHANICAL G061	FED FROM VFD-20
RAC-1	REMOTE AIR CONDITIONING UNIT	1	208 V	2	3.12		010PLSB1A	14,16	IT 10.1.034	15AMP MOCPP, PROVIDE LOCAL MOTOR RATED LOCKABLE DISCONNECT LOCATED NEXT TO UNIT. SEE HVAC DRAWINGS FOR ADDITIONAL INFORMATION
RAC-2	REMOTE AIR CONDITIONING UNIT	1	208 V	2	3.12		010PLSB2A	2,4	IT 10.2.013	15AMP MOCPP, PROVIDE LOCAL MOTOR RATED LOCKABLE DISCONNECT LOCATED NEXT TO UNIT. SEE HVAC DRAWINGS FOR ADDITIONAL INFORMATION
RAC-3	REMOTE AIR CONDITIONING UNIT	1	208 V	2	3.12		010PLSB3A	9,11	IT 10.3.004	15AMP MOCPP, PROVIDE LOCAL MOTOR RATED LOCKABLE DISCONNECT LOCATED NEXT TO UNIT. SEE HVAC DRAWINGS FOR ADDITIONAL INFORMATION
RAC-4	REMOTE AIR CONDITIONING UNIT	1	208 V	2	3.12		010PLSB3A	5,7	CRISIS PHONE ROOM 10.3.020	15AMP MOCPP, CEILING MOUNTED UNIT, PROVIDE LOCAL MOTOR RATED LOCKABLE DISCONNECT LOCATED NEXT TO UNIT. SEE HVAC DRAWINGS FOR ADDITIONAL INFORMATION
RE-2	ROOF EXHAUST FAN #2	1	120 V	1	0.696	1/4	010PL1BL	43	OCAC ROOFTOP	PROVIDE LOCAL MOTOR RATED DISCONNECTING MEANS. RATED AT 1HP WITH OVERLOAD PROTECTION.
RE-3	ROOF EXHAUST FAN #3	1	120 V	1	1.656	3/4	010PL3BL	4	OCAC ROOFTOP	PROVIDE LOCAL MOTOR RATED DISCONNECTING MEANS. RATED AT 1HP WITH OVERLOAD PROTECTION.
RE-4	ROOF EXHAUST FAN #4	1	120 V	1	0.696	1/4			MECHANICAL 03.3.174	PROVIDE NEW, EXTEND EXISTING AS REQUIRED. BREAKER SERVING UNIT SHALL BE SIZED AT 15 AMPS. SEE HVAC DRAWINGS H003 FOR ADDITIONAL INFORMATION.
RE-5	ROOF EXHAUST FAN #5	1	120 V	1	0.864	1/3	010PLSB3A	25	OCAC ROOFTOP	PROVIDE LOCAL MOTOR RATED DISCONNECTING MEANS. RATED AT 1HP WITH OVERLOAD PROTECTION.
RE-6	ROOF EXHAUST FAN #6	1	120 V	1	0.864	1/3	010PLSB2B	13	OCAC ROOFTOP	PROVIDE LOCAL MOTOR RATED DISCONNECTING MEANS. RATED AT 1HP WITH OVERLOAD PROTECTION.
RE-N2	RELIEF FAN	1	480 V	3	2.827	2			MECHANICAL 03.3.174	PROVIDE NEW CONDUIT, WIRING AND ALL TERMINATIONS FROM AND EXISTING PANEL LOCATION FOR REPLACEMENT OF UNIT. BREAKER SERVING UNIT SHALL BE SIZED AT 15 AMPS. SEE HVAC DRAWINGS H001 FOR ADDITIONAL INFORMATION.
RF-10-1	AC-1 RELIEF FAN	1	480 V	3	9.141	7.5	010MSB1A	10	MECHANICAL 10.1.145	FED FROM VFD LOCATED NEAR UNIT, PROVIDE VFD RATED WIRING TYPE XHHW-2 OR GREATER
RF-10-2	AC-2 RELIEF FAN	1	480 V	3	9.141	7.5	010DPH2A	13,15,17	MECHANICAL 10.2.084	FED FROM VFD LOCATED NEAR UNIT, PROVIDE VFD RATED WIRING TYPE XHHW-2 OR GREATER
RF-10-3	AC-3 RELIEF FAN	1	480 V	3	9.141	7.5	010DPH3A	13,15,17	MECHANICAL 10.3.123	FED FROM VFD LOCATED NEAR UNIT, PROVIDE VFD RATED WIRING TYPE XHHW-2 OR GREATER
SF-1	SUPPLY FAN BOILER ROOM	1	480 V	3	2.827	2			MECHANICAL G061	

SPECIAL OUTLET SCHEDULE									
CALLOUT	EQUIPMENT DESCRIPTION	COUNT	VOLTAGE	POLES	LOAD (kVA)	PANEL	CIRCUIT	LOCATION	NOTES
010ELEV-101	ELEVATOR #1	1	480 V	3	23.268	010DPHSB 1A	7,9,11	ELEVATOR 10.E1	PROVIDE 40AMP FEED TO ELECTRICAL CONTRACTOR SUPPLIED (FUSED) BUSSMANN POWER MODULE
010ELEV-102	ELEVATOR #2	1	480 V	3	23.268	010DPHSB 1A	8,10,12	ELEVATOR 10.E2	PROVIDE 40AMP FEED TO ELECTRICAL CONTRACTOR SUPPLIED (FUSED) BUSSMANN POWER MODULE
AUTO CLV	AUTO CLAVE	1	120 V	1	0.8	PNL 4	28	LAB 03.3.180	
BC	BATTERY CHARGER	1	120 V	1	1.1	010PL1AL	43	EXTERIOR NEAR GENERATOR	
BH	BLOCK HEATER	1	120 V	1	1.5	010PL1AL	42	EXTERIOR NEAR GENERATOR	
DTS	DRUG TESTING SOLENOID VALVE	1	120 V	1	0.2	010PL1BL	10	TOILET ROOM 10.1.009	PROVIDE CONNECTION, VALVE PROVIDED BY OTHERS
DTS	DRUG TESTING SOLENOID VALVE	1	120 V	1	0.2	PNL 3B	2	TOILET ROOM 03.2.109	PROVIDE CONNECTION, VALVE PROVIDED BY OTHERS
ELV 1 GFCI	ELEVATOR PIT RECEPTACLE	1	120 V	1	0.18	010PLSB1 A	12	ELEVATOR 10.E1	PROVIDE A WEATHER RESISTANT 20AMP GFCI RECEPTACLE IN A NEMA 4 BOX AND A HEAVY DUTY IN USE COVER.
ELV 1 GFCI	ELEVATOR MACHINE ROOM RECEPTACLE	1	120 V	1	0.18	010PLSB3 A	19	ELEVATOR 10.E1	PROVIDE A WEATHER RESISTANT 20AMP GFCI RECEPTACLE IN A NEMA 4 BOX AND A HEAVY DUTY IN USE COVER.
ELV 2 GFCI	ELEVATOR PIT RECEPTACLE	1	120 V	1	0.18	010PLSB2 B	1	ELEVATOR 10.E2	PROVIDE A WEATHER RESISTANT 20AMP GFCI RECEPTACLE IN A NEMA 4 BOX AND A HEAVY DUTY IN USE COVER.
ELV 2 GFCI	ELEVATOR MACHINE ROOM RECEPTACLE	1	120 V	1	0.18	010PLSB2 B	10	ELEVATOR 10.E2	PROVIDE A WEATHER RESISTANT 20AMP GFCI RECEPTACLE IN A NEMA 4 BOX AND A HEAVY DUTY IN USE COVER.
ELVCL-1	ELEVATOR CAR LIGHTING CONNECTION	1	120 V	1	1.44	010PLEM1 B	16	ELEVATOR 10.E1	PROVIDE FUSED/BREAKER LOCKABLE DISCONNECT AND CONNECTIONS AS REQUIRED FOR CAR LIGHTING
ELVCL-2	ELEVATOR CAR LIGHTING CONNECTION	1	120 V	1	1.44	010PLEM3 A	1	ELEVATOR 10.E2	PROVIDE FUSED/BREAKER LOCKABLE DISCONNECT AND CONNECTIONS AS REQUIRED FOR CAR LIGHTING
FF-1	FURNITURE FEED	1	120 V	1	0.96	010PL1BL	18	OPEN OFFICE 10.1.022	PROVIDE HARDWIRE CONNECTION TO WORKSTATION FURNITURE
FF-2	FURNITURE FEED	1	120 V	1	1.08	010PL1BL	20	OPEN OFFICE 10.1.022	PROVIDE HARDWIRE CONNECTION TO WORKSTATION FURNITURE
FF-3	FURNITURE FEED	1	120 V	1	0.72	010PL1BL	16	OPEN OFFICE 10.1.022	PROVIDE HARDWIRE CONNECTION TO WORKSTATION FURNITURE
FF-4	FURNITURE FEED	1	120 V	1	0.9			OPEN OFFICE 01.3.002	PROVIDE HARDWIRE CONNECTION TO WORKSTATION FURNITURE
FF-5	FURNITURE FEED	1	120 V	1	1.2	010PL1BR	23	WAITING ROOM 10.1.031	PROVIDE HARDWIRE CONNECTION TO WORKSTATION FURNITURE
FF-6	FURNITURE FEED	1	120 V	1	1.2	010PL1BR	24	WAITING ROOM 10.1.031	PROVIDE HARDWIRE CONNECTION TO WORKSTATION FURNITURE
FF-7	FURNITURE FEED	1	120 V	1	0.72	010PL1BR	26	WAITING ROOM 10.1.031	PROVIDE HARDWIRE CONNECTION TO WORKSTATION FURNITURE
FF-8	FURNITURE FEED	1	120 V	1	0.72	010PL1BR	26	WAITING ROOM 10.1.031	PROVIDE HARDWIRE CONNECTION TO WORKSTATION FURNITURE
FF-9	FURNITURE FEED	1	120 V	1	0.72	010PL1BR	27	WAITING ROOM 10.1.031	PROVIDE HARDWIRE CONNECTION TO WORKSTATION FURNITURE
FF-10	FURNITURE FEED	1	120 V	1	1.2	010PL1BR	29	WAITING ROOM 10.1.031	PROVIDE HARDWIRE CONNECTION TO WORKSTATION FURNITURE
FF-11	FURNITURE FEED	1	120 V	1	0.9	010PL2B	32	OPEN OFFICE 10.2.027	PROVIDE HARDWIRE CONNECTION TO WORKSTATION FURNITURE
FF-12	FURNITURE FEED	1	120 V	1	0.9	010PL2B	20	OPEN OFFICE 10.2.022	PROVIDE HARDWIRE CONNECTION TO WORKSTATION FURNITURE
FF-13	FURNITURE FEED	1	120 V	1	0.9	010PL2B	19	OPEN OFFICE 10.2.022	PROVIDE HARDWIRE CONNECTION TO WORKSTATION FURNITURE
FF-14	FURNITURE FEED	1	120 V	1	1.2	010PL3A	13	OPEN OFFICE 10.3.136	PROVIDE HARDWIRE CONNECTION TO WORKSTATION FURNITURE
FF-15	FURNITURE FEED	1	120 V	1	1.2	010PL1AR	33	OPEN OFFICE 10.1.139	PROVIDE HARDWIRE CONNECTION TO WORKSTATION FURNITURE
FF-16	FURNITURE FEED	1	120 V	1	1.62	010PL3BR	7	OPEN OFFICE 10.3.083	PROVIDE HARDWIRE CONNECTION TO WORKSTATION FURNITURE
FF-17	FURNITURE FEED	1	120 V	1	1.2	010PL1AR	35	OPEN OFFICE 10.1.139	PROVIDE HARDWIRE CONNECTION TO WORKSTATION FURNITURE
FF-18	FURNITURE FEED	1	120 V	1	0.9	GNLB	12	OPEN OFFICE 04.0.005	PROVIDE HARDWIRE CONNECTION TO WORKSTATION FURNITURE
FF-19	FURNITURE FEED	1	120 V	1	1.5	010PL1AL	29	OPEN OFFICE 10.1.139	PROVIDE HARDWIRE CONNECTION TO WORKSTATION FURNITURE
FF-20	FURNITURE FEED	1	120 V	1	1.2	PNL 3	32	OPEN OFFICE 03.2.113	PROVIDE HARDWIRE CONNECTION TO WORKSTATION FURNITURE
FF-21	FURNITURE FEED	1	120 V	1	0.8	PNL 3	29	OPEN OFFICE 03.2.113	PROVIDE HARDWIRE CONNECTION TO WORKSTATION FURNITURE
FF-22	FURNITURE FEED	1	120 V	1	0.6	PNL 3	31	OPEN OFFICE 03.2.113	PROVIDE HARDWIRE CONNECTION TO WORKSTATION FURNITURE
FF-23	FURNITURE FEED	1	120 V	1	0.8	PNL 3	25	OPEN OFFICE 03.2.113	PROVIDE HARDWIRE CONNECTION TO WORKSTATION FURNITURE
FF-24	FURNITURE FEED	1	120 V	1	1.2	GNLD	14	OPEN OFFICE 04.1.036	PROVIDE HARDWIRE CONNECTION TO WORKSTATION FURNITURE
FF-25	FURNITURE FEED	1	120 V	1	1.2	GNLD	15	OPEN OFFICE 04.1.036	PROVIDE HARDWIRE CONNECTION TO WORKSTATION FURNITURE
FF-26	FURNITURE FEED	1	120 V	1	1.2	GNLD	46	OPEN OFFICE 04.1.008	PROVIDE HARDWIRE CONNECTION TO WORKSTATION FURNITURE
FF-27	FURNITURE FEED	1	120 V	1	1.2	GNLD	37	OPEN OFFICE 04.1.008	PROVIDE HARDWIRE CONNECTION TO WORKSTATION FURNITURE
FF-28	FURNITURE FEED	1	120 V	1	1.2	GNLD	36	OPEN OFFICE 04.1.008	PROVIDE HARDWIRE CONNECTION TO WORKSTATION FURNITURE
FF-29	FURNITURE FEED	1	120 V	1	0.6	GNLD	32	OPEN OFFICE 04.1.004	PROVIDE HARDWIRE CONNECTION TO WORKSTATION FURNITURE
FF-30	FURNITURE FEED	1	120 V	1	0.6	GNLD	28	OPEN OFFICE 04.1.004	PROVIDE HARDWIRE CONNECTION TO WORKSTATION FURNITURE

SPECIAL OUTLET SCHEDULE (CONT. 1)									
CALLOUT	EQUIPMENT DESCRIPTION	COUNT	VOLTAGE	POLES	LOAD (kVA)	PANEL	CIRCUIT	LOCATION	NOTES
FF-31	FURNITURE FEED	1	120 V	1	1.2	PNL 68	11	OPEN OFFICE 01.1.030	PROVIDE HARDWIRE CONNECTION TO WORKSTATION FURNITURE
FF-32	FURNITURE FEED	1	120 V	1	1.2	PNL 68	17	OPEN OFFICE 01.1.023	PROVIDE HARDWIRE CONNECTION TO WORKSTATION FURNITURE
FF-33	FURNITURE FEED	1	120 V	1	1.2	PNL 68	9	OPEN OFFICE 01.1.023	PROVIDE HARDWIRE CONNECTION TO WORKSTATION FURNITURE
FG-1	FIRE GATE	1	120 V	1	1.176	010PLEM1 A	2	LOBBY 01.1.002	PROVIDE A LOCAL DISCONNECTING MEANS CAPABLE OF BEING LOCKED IN THE OPEN AND CLOSED POSITION. VERIFY VOLTAGE, AMP DRAW AND INSTALLATION REQUIREMENTS WITH GATE SUPPLIER PRIOR TO INSTALLATION.
FG-2	FIRE GATE	1	120 V	1	1.176	010PLEM1 B	18	CORRIDOR 10.3.001	PROVIDE A LOCAL DISCONNECTING MEANS CAPABLE OF BEING LOCKED IN THE OPEN AND CLOSED POSITION. VERIFY VOLTAGE, AMP DRAW AND INSTALLATION REQUIREMENTS WITH GATE SUPPLIER PRIOR TO INSTALLATION.
FG-3	FIRE GATE	1	120 V	1	1.176	010PLEM1 B	17	CORRIDOR 10.3.009	PROVIDE A LOCAL DISCONNECTING MEANS CAPABLE OF BEING LOCKED IN THE OPEN AND CLOSED POSITION. VERIFY VOLTAGE, AMP DRAW AND INSTALLATION REQUIREMENTS WITH GATE SUPPLIER PRIOR TO INSTALLATION.
FLOW SWITCH	FLOW SWITCH (RISER) LEVEL 790.00	1	120 V	1	0.1			MECHANICAL 10.1.145	PROVIDE LOCAL LOCKABLE DISCONNECTING MEANS LOCATED ADJACENT TO FLOW SWITCH AND BREAKER LOCK OB BREAKER FEEDING DEVICE. PROVIDE A 120VAC CONNECTION AS REQUIRED. VERIFY FINAL SUBMITTAL DOCUMENTATION PRIOR TO INSTALLATION.
FLOW SWITCH	FLOW SWITCH (RISER) LEVEL 805.00	1	120 V	1	0.1			MECHANICAL 10.2.084	PROVIDE LOCAL LOCKABLE DISCONNECTING MEANS LOCATED ADJACENT TO FLOW SWITCH AND BREAKER LOCK OB BREAKER FEEDING DEVICE. PROVIDE A 120VAC CONNECTION AS REQUIRED. VERIFY FINAL SUBMITTAL DOCUMENTATION PRIOR TO INSTALLATION.
FLOW SWITCH	FLOW SWITCH (RISER) LEVEL 820.00	1	120 V	1	0.1			MECHANICAL 10.3.123	PROVIDE LOCAL LOCKABLE DISCONNECTING MEANS LOCATED ADJACENT TO FLOW SWITCH AND BREAKER LOCK OB BREAKER FEEDING DEVICE. PROVIDE A 120VAC CONNECTION AS REQUIRED. VERIFY FINAL SUBMITTAL DOCUMENTATION PRIOR TO INSTALLATION.
INC	INCUBATOR	1	120 V	1	0.8	PNL 4	25	LAB 03.3.180	
INC	INCUBATOR	1	120 V	1	0.8	PNL 4	24	LAB 03.3.180	
PA-1	POWER ASSIST DOOR CONTROLLER	1	120 V	1	0.72	010PLEM1 B	1	NON-SECURE VESTIBULE 10.1.001	PROVIDE CONNECTION TO POWER ASSIST CONTROLLER, BOXES IN WALLS AND WIRING/TERMINATIONS FROM CONTROLLER TO EACH ASSIST BUTTON LOCATION
PA-2	POWER ASSIST DOOR CONTROLLER	1	120 V	1	0.72	010PLEM1 B	2	NON-SECURE VESTIBULE 10.1.001	PROVIDE CONNECTION TO POWER ASSIST CONTROLLER, BOXES IN WALLS AND WIRING/TERMINATIONS FROM CONTROLLER TO EACH ASSIST BUTTON LOCATION
PA-3	POWER ASSIST DOOR CONTROLLER	1	120 V	1	0.72	010PLEM1 B	3	NON-SECURE VESTIBULE 10.1.001	PROVIDE CONNECTION TO POWER ASSIST CONTROLLER, BOXES IN WALLS AND WIRING/TERMINATIONS FROM CONTROLLER TO EACH ASSIST BUTTON LOCATION
PA-4	POWER ASSIST DOOR CONTROLLER	1	120 V	1	0.72	010PLEM1 B	4	NON-SECURE VESTIBULE 10.1.001	PROVIDE CONNECTION TO POWER ASSIST CONTROLLER, BOXES IN WALLS AND WIRING/TERMINATIONS FROM CONTROLLER TO EACH ASSIST BUTTON LOCATION
PA-5	POWER ASSIST DOOR CONTROLLER	1	120 V	1	0.72	010PLEM1 B	5	VESTIBULE 10.1.002	PROVIDE CONNECTION TO POWER ASSIST CONTROLLER, BOXES IN WALLS AND WIRING/TERMINATIONS FROM CONTROLLER TO EACH ASSIST BUTTON LOCATION
PA-6	POWER ASSIST DOOR CONTROLLER	1	120 V	1	0.72	010PLEM1 B	6	VESTIBULE 10.1.002	PROVIDE CONNECTION TO POWER ASSIST CONTROLLER, BOXES IN WALLS AND WIRING/TERMINATIONS FROM CONTROLLER TO EACH ASSIST BUTTON LOCATION
PA-7	POWER ASSIST DOOR CONTROLLER	1	120 V	1	0.72	010PLEM1 B	7	CORRIDOR 10.1.006	PROVIDE CONNECTION TO POWER ASSIST CONTROLLER, BOXES IN WALLS AND WIRING/TERMINATIONS FROM CONTROLLER TO EACH ASSIST BUTTON LOCATION
PA-8	POWER ASSIST DOOR CONTROLLER	1	120 V	1	0.72	010PLEM1 B	8	CORRIDOR 10.1.006	PROVIDE CONNECTION TO POWER ASSIST CONTROLLER, BOXES IN WALLS AND WIRING/TERMINATIONS FROM CONTROLLER TO EACH ASSIST BUTTON LOCATION
PA-9	POWER ASSIST DOOR CONTROLLER	1	120 V	1	0.72	010PL1BL	29	MENS 10.1.026	PROVIDE CONNECTION TO POWER ASSIST CONTROLLER, BOXES IN WALLS AND WIRING/TERMINATIONS FROM CONTROLLER TO EACH ASSIST BUTTON LOCATION
PA-10	POWER ASSIST DOOR CONTROLLER	1	120 V	1	0.72	010PL1BL	28	WOMENS 10.1.027	PROVIDE CONNECTION TO POWER ASSIST CONTROLLER, BOXES IN WALLS AND WIRING/TERMINATIONS FROM CONTROLLER TO EACH ASSIST BUTTON LOCATION
PA-11	POWER ASSIST DOOR CONTROLLER	1	120 V	1	0.72	010PLEM1 B	10	CORRIDOR 10.1.028	PROVIDE CONNECTION TO POWER ASSIST CONTROLLER, BOXES IN WALLS AND WIRING/TERMINATIONS FROM CONTROLLER TO EACH ASSIST BUTTON LOCATION
PA-12	POWER ASSIST DOOR CONTROLLER	1	120 V	1	0.72	010PLEM1 B	11	CORRIDOR 10.1.038	PROVIDE CONNECTION TO POWER ASSIST CONTROLLER, BOXES IN WALLS AND WIRING/TERMINATIONS FROM CONTROLLER TO EACH ASSIST BUTTON LOCATION

[illegible]

PLUMBING EQUIPMENT SCHEDULE											
CALLOUT	EQUIPMENT DESCRIPTION	COUNT	VOLTAGE	POLES	LOAD (kVA)	HORSEPOWER	PANEL	CIRCUIT	LOCATION	NOTES	
EW-C-1	ELECTRIC WATER COOLER	1	120 V	1	0.504		010PL3BL	1	WAITING ROOM 10.3.010	PROVIDE GFCI PROTECTION FROM PANEL SERVED, VERIFY FINAL MOUNTING HEIGHT	
EW-C-2	ELECTRIC WATER COOLER	1	120 V	1	0.504		010PL1BL	32	CORRIDOR 10.1.006	PROVIDE GFCI PROTECTION FROM PANEL SERVED, VERIFY FINAL MOUNTING HEIGHT	
EW-C-2	ELECTRIC WATER COOLER	1	120 V	1	0.504		010PL1AR	28	CORRIDOR 10.1.028	PROVIDE GFCI PROTECTION FROM PANEL SERVED, VERIFY FINAL MOUNTING HEIGHT	
EW-C-2	ELECTRIC WATER COOLER	1	120 V	1	1.008		010PL2B	48	CORRIDOR 10.2.001	PROVIDE GFCI PROTECTION FROM PANEL SERVED, VERIFY FINAL MOUNTING HEIGHT	
EW-C-2	ELECTRIC WATER COOLER	1	120 V	1	0.504		010PL2A	1	CORRIDOR 10.2.031	PROVIDE GFCI PROTECTION FROM PANEL SERVED, VERIFY FINAL MOUNTING HEIGHT	
EW-C-2	ELECTRIC WATER COOLER	1	120 V	1	0.504		010PL3BL	19	CORRIDOR 10.3.001	PROVIDE GFCI PROTECTION FROM PANEL SERVED, VERIFY FINAL MOUNTING HEIGHT	
EW-C-2	ELECTRIC WATER COOLER	1	120 V	1	0.504		010PL3A	1	CORRIDOR 10.3.009	PROVIDE GFCI PROTECTION FROM PANEL SERVED, VERIFY FINAL MOUNTING HEIGHT	
EW-C-2	ELECTRIC WATER COOLER	1	120 V	1	0.504		LPBB	10	CORRIDOR 03.1.206	PROVIDE GFCI PROTECTION FROM PANEL SERVED, VERIFY FINAL MOUNTING HEIGHT	
HWRP-1	DOMESTIC HOT WATER CIRCULATING PUMP	1	120 V	1	0.528	1/6			ELECTRICAL 03.3.172	CIRC PUMP CONTROLLER PROVIDED BY OTHERS, INSTALLED AND TERMINATED BY ELECTRICAL CONTRACTOR PROVIDE LOCAL LOCKABLE MANUAL MOTOR RATED DISCONNECTING MEANS AND TERMINATIONS	
HWRP-2	HOT WATER RECIRCULATING PUMP (EXISTING)	1	208 V	2	1.123	1/2			ELECTRICAL 03.3.172	EXISTING RELOCATED FROM HHS NORTH ROOM 03.0.036.	
HWRP-3	RECIRCULATING PUMP (EXISTING)	1	208 V	3	0.865	1/2			ELECTRICAL 03.3.172	EXISTING RELOCATED FROM HHS NORTH ROOM 03.0.036.	
ODS-1	ELEVATOR PIT OIL DETECTION SYSTEM MODEL OA-2100	1	120 V	1	0.36		010PLSB1A	13	ELEVATOR 10.E1	PROVIDE A SINGLE WEATHER RESISTANT 20AMP RECEPTACLE IN A NEMA 4 BOX AND A HEAVY DUTY IN USE COVER.	
ODS-2	ELEVATOR PIT OIL DETECTION SYSTEM MODEL OA-2100	1	120 V	1	0.36		010PLSB2B	2	ELEVATOR 10.E2	PROVIDE A SINGLE WEATHER RESISTANT 20AMP RECEPTACLE IN A NEMA 4 BOX AND A HEAVY DUTY IN USE COVER.	
WH-1	WATER HEATER (EXISTING)	1	120 V	1	0.6				ELECTRICAL 03.3.172	EXISTING RELOCATED FROM HHS NORTH ROOM 03.0.036.	
WH-2	WATER HEATER	1	120 V	1	0.6				ELECTRICAL 03.3.172	PROVIDE LOCAL LOCKABLE MANUAL MOTOR RATED DISCONNECTING MEANS AND TERMINATIONS	


ALTERATION / ADDITION
OUTAGAMIE COUNTY ADMINISTRATION CENTER
S. WALNUT & W. 8TH, APPLETON WI 54911
PLUMBING SCHEDULE

DESIGNED	DRAWN
RJW	MAL
PROJECT NO.	
00002-61600160	
DATE	
MARCH 3, 2017	
SHEET NO.	


EP805

Mcmahon provides this drawing as instruments of service. All rights are reserved by McMahon. The client agrees to indemnify and hold McMahon harmless from and against all claims, damages, costs and expenses, including reasonable attorneys' fees, arising out of or from the use of the original drawings created by McMahon.

McMAHON
ENGINEERS ARCHITECTS
1025 N. KENNAWAY, VI
MILWAUKEE, WI 53233
Tel: (920) 751-4200 Fax: (920) 751-4284
www.mcmahoneng.com

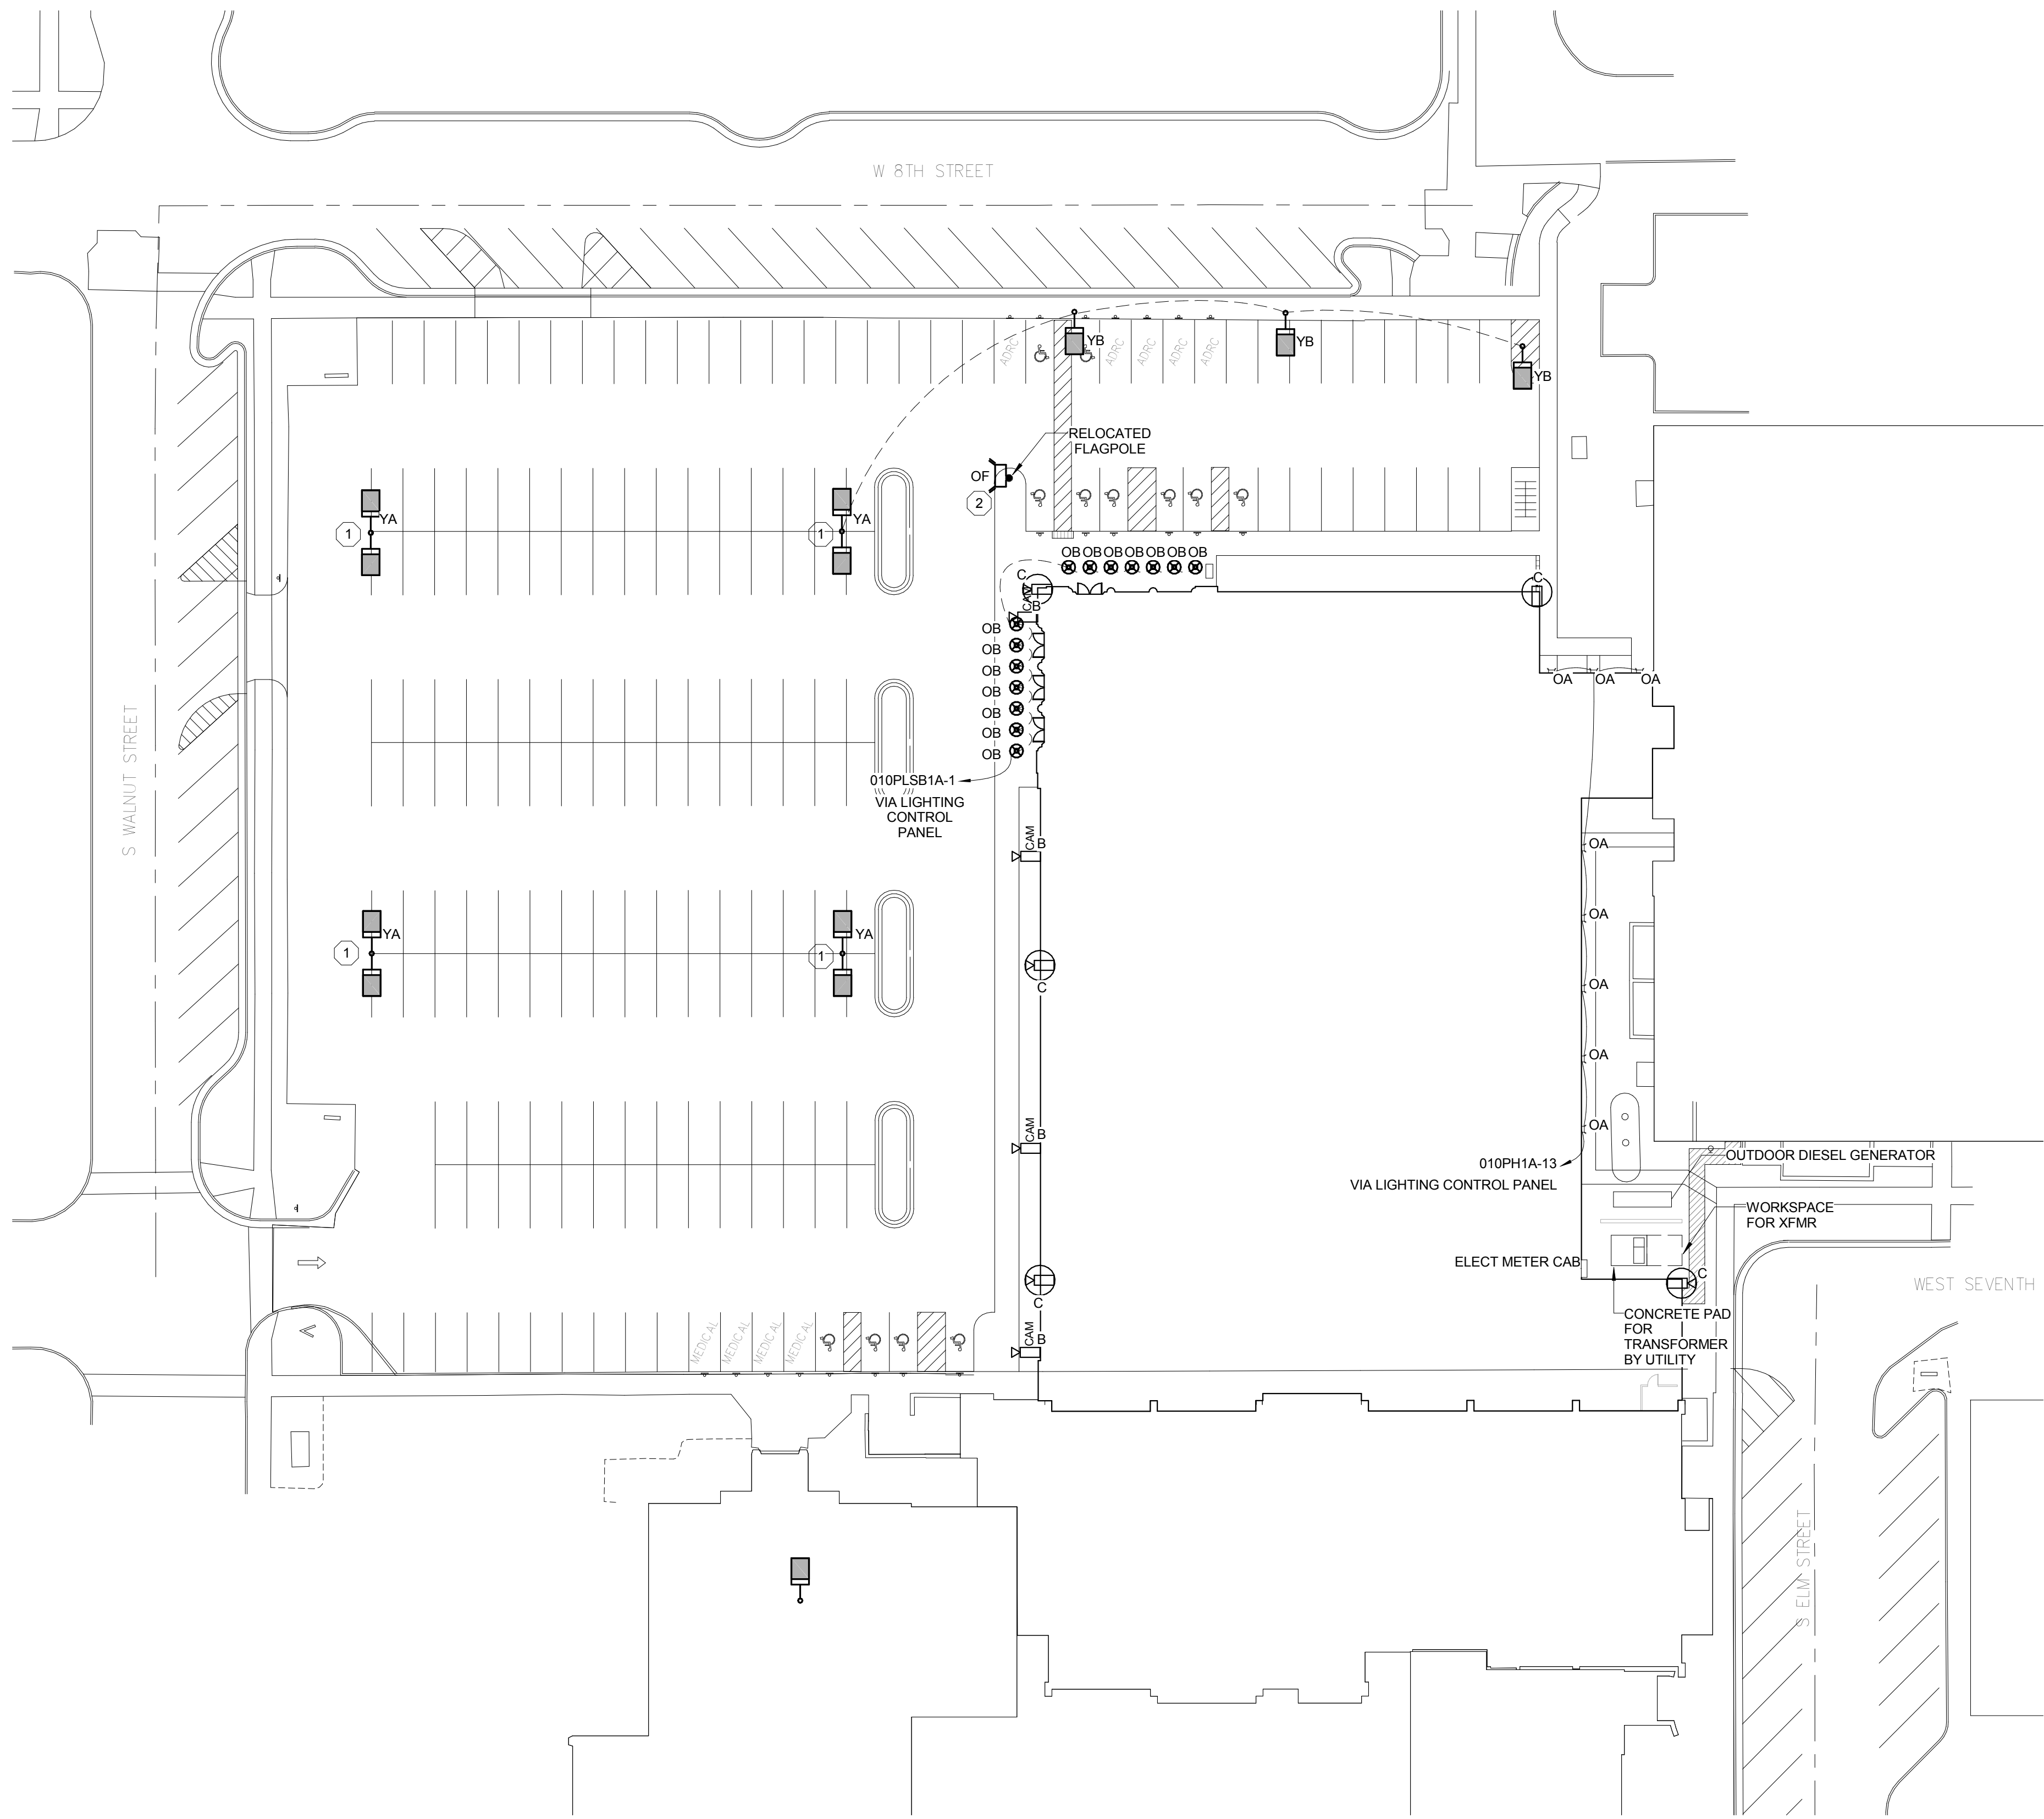

1 SITE ELECTRICAL PLAN
Scale: 1" = 30'-0"

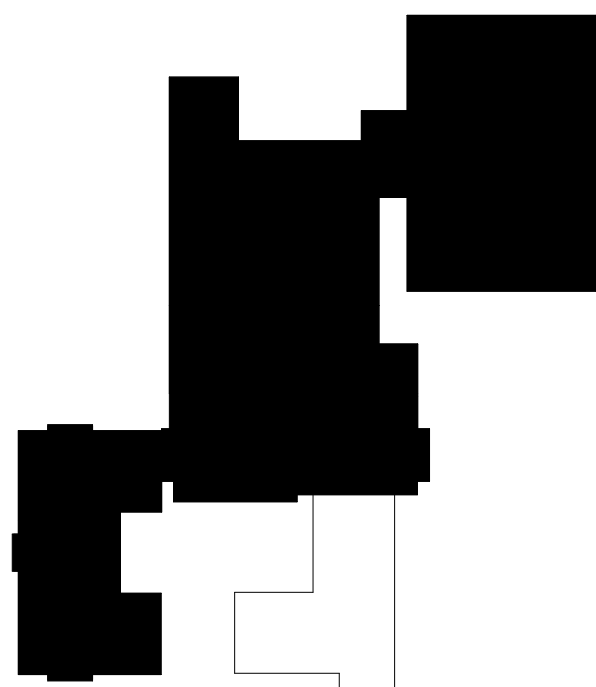

PLAN KEY



PLAN NOTES: #

1. EXISTING FIXTURE AND POLE TO REMAIN. EXISTING CIRCUITRY BETWEEN FIXTURES TO REMAIN. CONNECT EXISTING FIXTURES TO NEW SITE LIGHTING WIRING AND CONTROLS.
2. FLAGPOLE LIGHTING, MOUNTED ON FLAG POLE AT 9'-0" ABOVE FINISHED GRADE.


DESIGNED	DRAWN
JMM	MAL
PROJECT NO.	
00002-61600160	
DATE	
MARCH 3, 2017	
SHEET NO.	

ES101

ALTERATION / ADDITION
OUTAGAMIE COUNTY ADMINISTRATION CENTER
S. WALNUT & W. 8TH, APPLETON WI 54911
SITE ELECTRICAL PLAN

McMahon provides this drawing as instruments of service. All work shown herein shall be installed by McMahon. The client shall be responsible for obtaining all necessary permits and for securing all required approvals. McMahon shall not be responsible for any changes made to the original drawing without the written consent of McMahon.

McMAHON
ENGINEERS ARCHITECTS
1000 N. KENNAWAY AVENUE
MILWAUKEE, WI 53233
Tel: (820) 751-4200 Fax: (820) 751-4284
www.mhngp.com

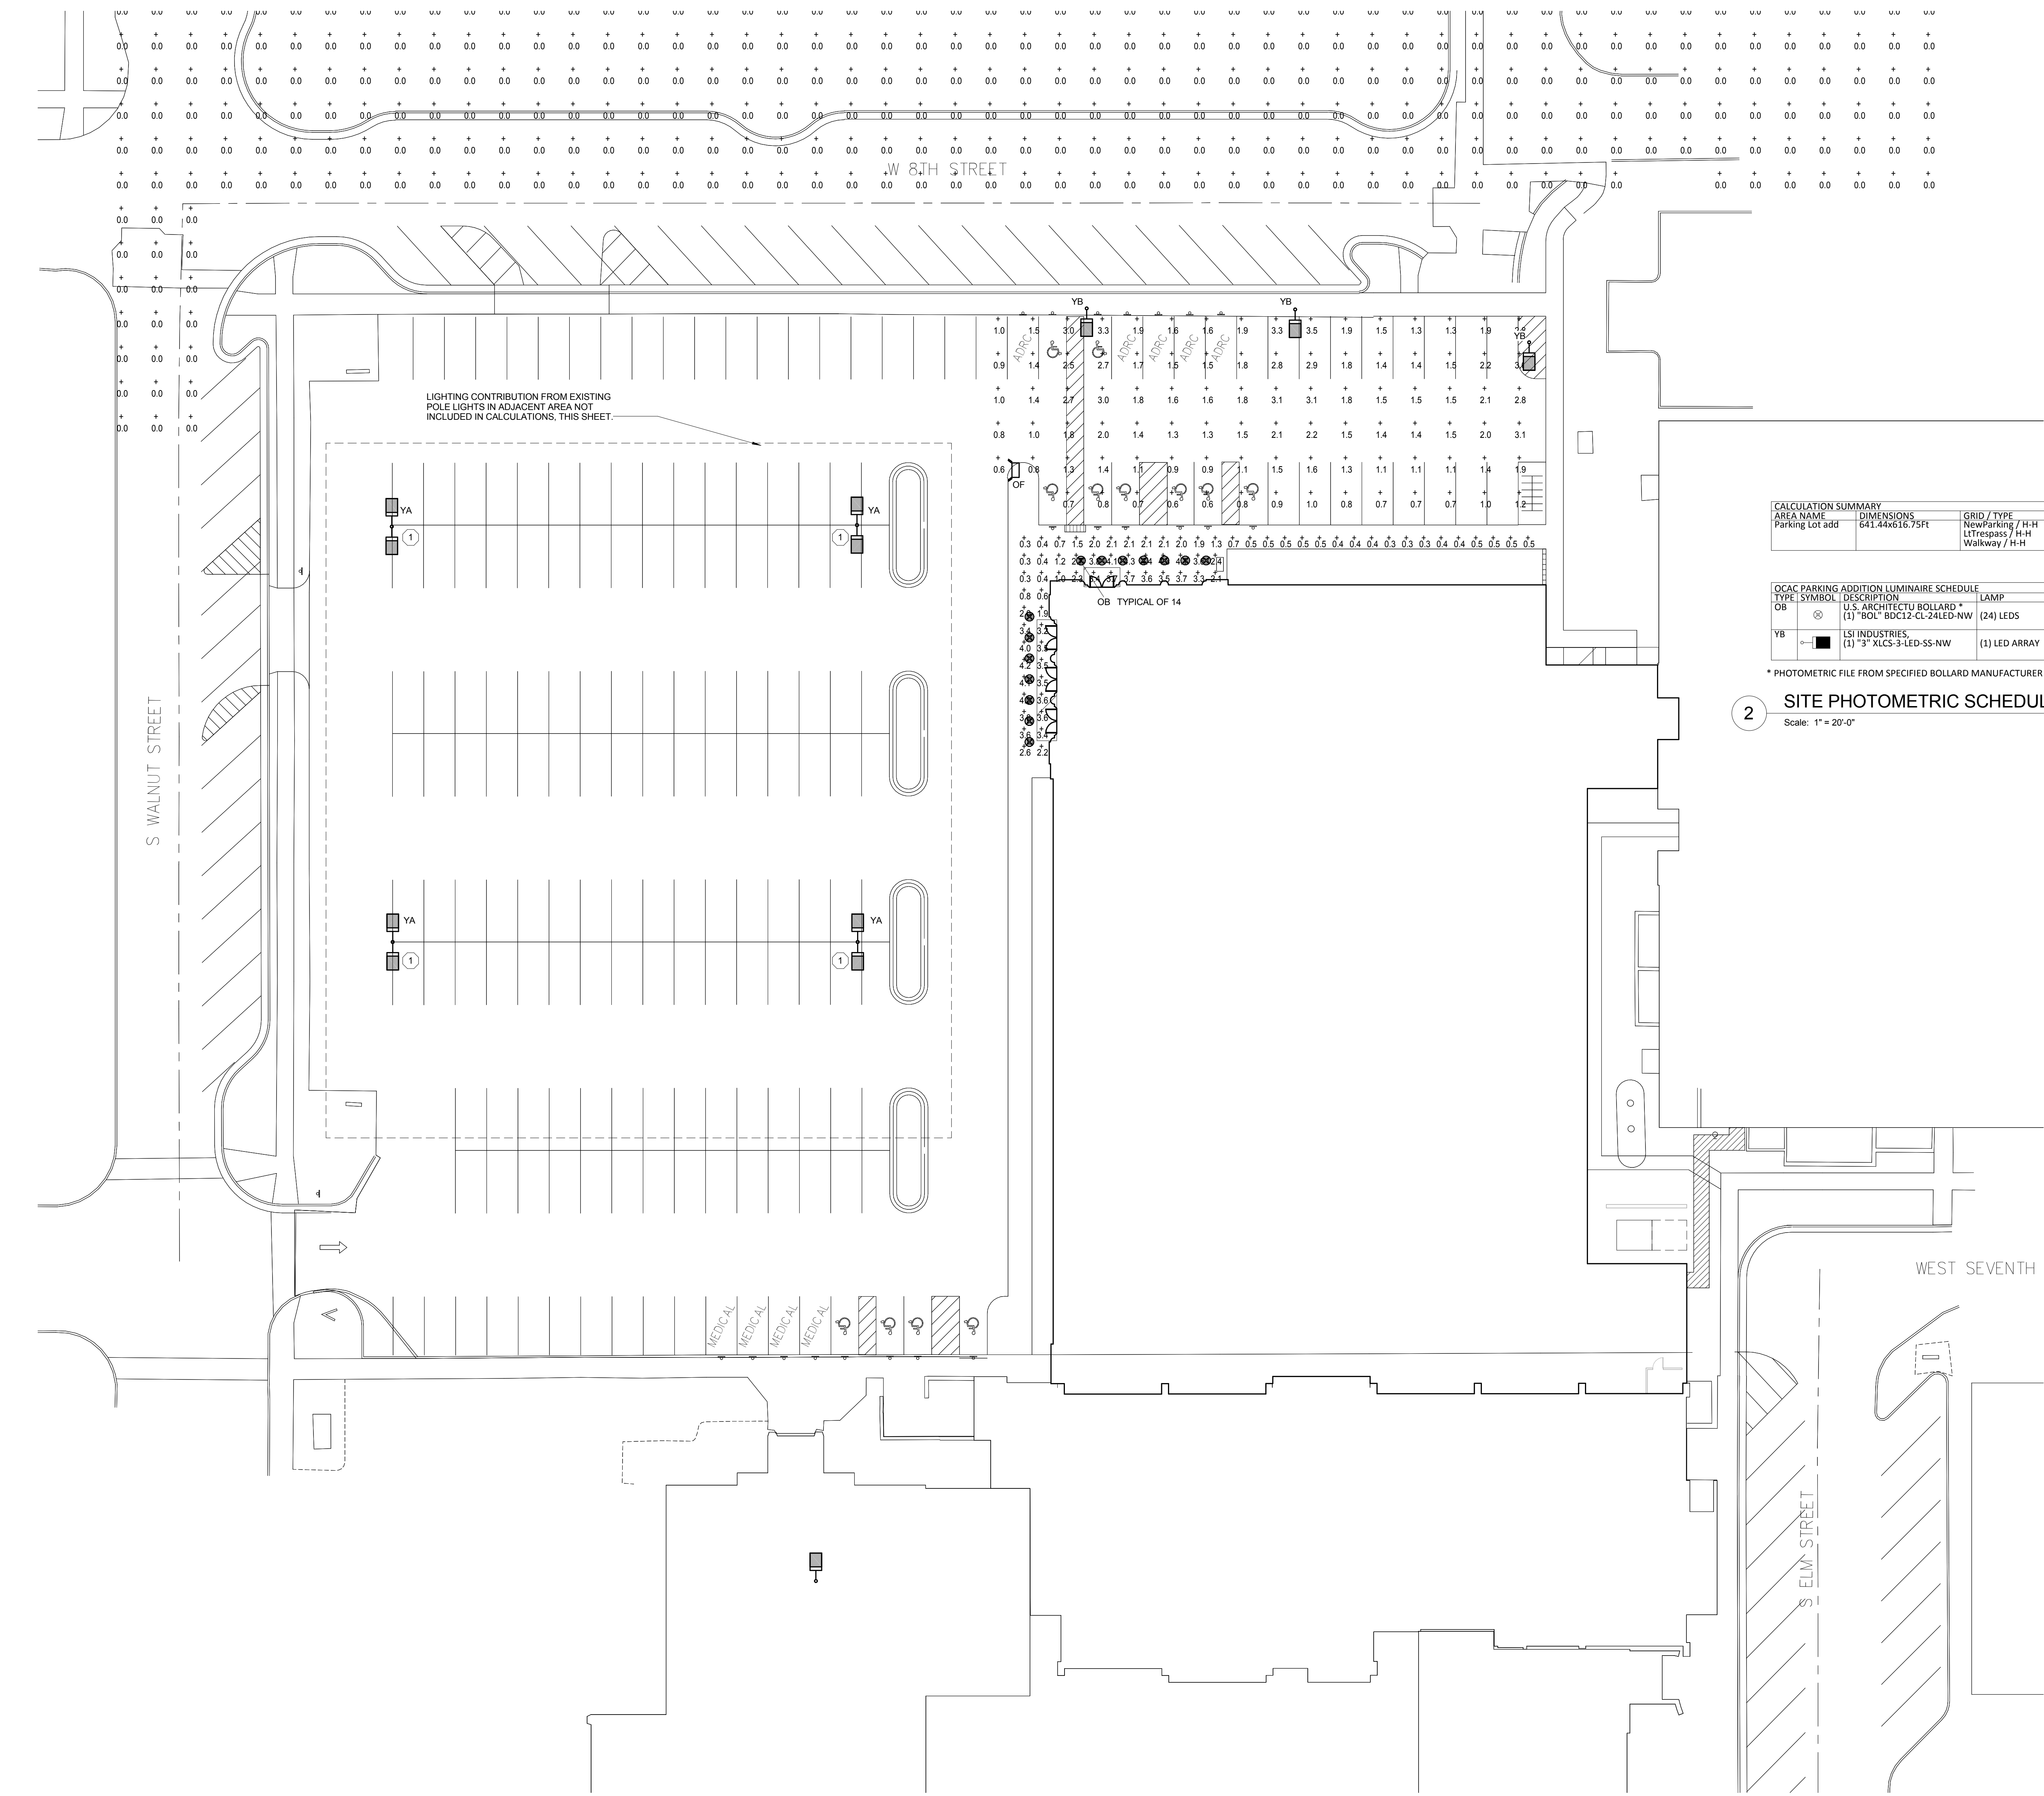

PLAN NOTES: 1. EXISTING FIXTURE AND POLE TO REMAIN. EXISTING CIRCUITRY BETWEEN FIXTURES TO REMAIN. CONNECT EXISTING FIXTURES TO NEW SITE LIGHTING WIRING AND CONTROLS.


CALCULATION SUMMARY										
AREA NAME	DIMENSIONS	GRID / TYPE	# PTS	SPACING	GROUP	AVE	MAX	MIN	MAX/MIN	AVE/MIN
Parking Lot add	641.44x616.75FT	NewPaving / H-H	94	10.00	<=>	1.64	3.57	0.56	6.37	2.93
		LTrespass / H-H	337	10.00	<=>	0.00	0.03	0.00	N/A	N/A
		Walkway / H-H	74	5.00	<=>	2.09	4.35	0.27	16.23	7.81

OCAC PARKING ADDITION LUMINAIRE SCHEDULE					
TYPE	SYMBOL	DESCRIPTION	LAMP	LUMENS MOUNTING/BALLAST	LF/ QTY
OB	⊗	U.S. ARCHITECTU BOLLARD * (1) BOLL - BOLL-24-LED-NW	(24) LEDS	757 LED BOLLARD - DIMMED	0.60 14
YB	■	ISI INDUSTRIES (1) "3" XLCS-3-LED-SS-NW	(1) LED ARRAY	10170 30' POLE, 2' BASE	0.90 3

* PHOTOMETRIC FILE FROM SPECIFIED BOLLARD MANUFACTURER IS NOT AVAILABLE, THIS FILE WAS USED TO APPROXIMATE BOLLARD LIGHTING.

2 SITE PHOTOMETRIC SCHEDULE
Scale: 1" = 20'-0"

1 SITE ELECTRICAL PLAN PHOTOMETRIC
Scale: 1" = 20'-0"

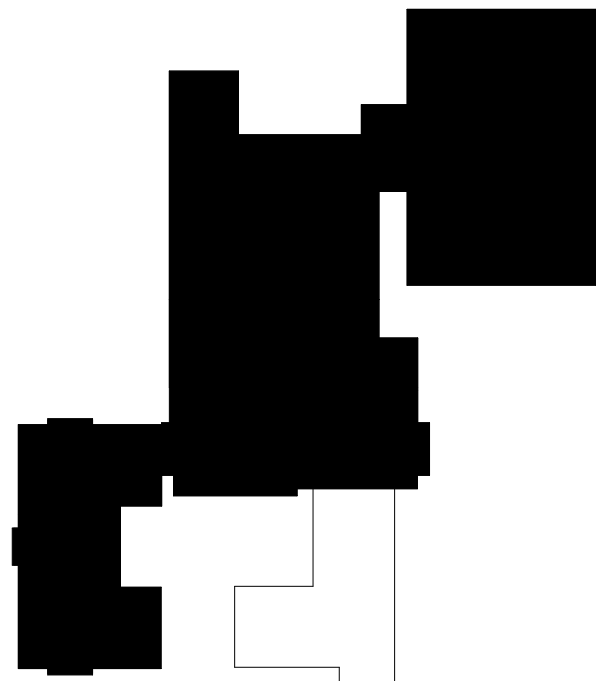

SITE LIGHTING FIXTURE SCHEDULE										
TYPE	DESCRIPTION	MANUFACTURER	CATALOG NUMBER	LAMP TYPE	LAMP COLOR	LAMP QTY PER FIXTURE	VOLTAGE	WATTAGE	NOTES	
OA	LED WALL PACK - FULL CUTOFF WITH DIFFUSER	HUBBELL	LNC2 7L U 4K 3 "FINISH" PC / 93044013	LED	4000 K	1	277 V	17W	1	
OB	18" DIAMETER X 35" H REINFORCED CONCRETE BOLLARD	WAUSAU MADE	BOLLARD TF6051 WITH TF8025 LED LIGHT FIXTURE	LED	4000 K	1	120 V	13W	1	
OF	LED FLAG POLE LIGHT - POLE MOUNTED	LITHONIA	DSXF1 P1 40K NSP MVOLT DNAXD	LED	4000 K	1	277 V	21W	1	
YA	EXISTING TO REMAIN				4000 K		120 V	0W		
YB	LED AREA LIGHT WITH 30" POLE AND 30" CONCRETE BASE	LSI INDUSTRIES	XLCS 3 LED NW UE BRZ	LED	4000 K	1	277 V	140W	1	

SITE LIGHTING SCHEDULE NOTES:

1. CONFIRM COLOR WITH ARCHITECT/TOWNER. VERIFY ALL MOUNTING REQUIREMENTS.

LED AREA LIGHTS - LSI SLICE SMALL (XLCS)



LSI LIGHTING FACTS
Department of Energy has verified representative product test data and results in accordance with the Lighting Facts Program. Visit www.lightingfacts.com for specific catalog ratings.

LIGHT OUTPUT - XLCS						
		Lumen (Nominal)				Max. (Nominal)
		Type 3	Type FT	Type 5	TypeBTE	
Cool White	3000K	10100	11400	11400	8200	7800
	4000K	14000	15500	15700	11900	10600
Neutral White	5000K	9700	10400	10800	7900	7500
	6000K	13400	14700	15200	11300	10500



COMcheck Software Version 4.0.5.2
Exterior Lighting Compliance
Certificate

Section 1: Project Information

Energy Code: 2009 IECC
Project Title:
Project Type: Addition
Exterior Lighting Zone: 2 (Neighborhood business district)
Construction Site: S. Walnut St. and W. 8th Street
Appleton, WI 54911
Owner/Agent:
Designer/Contractor: Nancy Kanter, LC
Faith Technologies, Inc.
201 Main St., Suite 1
Menasha, WI
920 751 9928
nancy.kanter@faithtechnologies.com

Section 2: Exterior Lighting Area/Surface Power Calculation

A Exterior Area/Surface	B Quantity	C Allowed Watts / Unit	D Tradable Wattage	E Allowed Watts (B x C)	F Proposed Watts
Parking area	12012 B2	0.06	Yes	721	420
Main entry 18 ft of door width	20	Yes	360	182	
Other door (not main entry) 6 ft of door width	20	Yes	120	140	
Total Tradable Watts* =				1201	742
Total Allowed Watts =				1201	
Total Allowed Supplemental Watts** =				600	

* Wattage tradeoffs are only allowed between tradable areas/surfaces.
** A supplemental allowance equal to 600 watts may be applied toward compliance of both non-tradable and tradable areas/surfaces.

Section 3: Exterior Lighting Fixture Schedule

A Fixture ID : Description / Lamp / Wattage Per Lamp / Ballast	B Lamps/ Fixture	C # of Fixtures	D Fixture Watt.	E (C X D)
Parking area (12012 B2): Tradable Wattage LED 1: Y8: FULL CUTOFF TYPE 3 POLE MTD: LED Roadway-Parking Unit 130W:	1	3	140	420
Main entry (18 ft of door width): Tradable Wattage LED 2: O8: CONCRETE BOLLARDS: LED Other Fixture Unit 16W:	1	14	13	182
Other door (not main entry) (6 ft of door width): Tradable Wattage LED 3: OF: FLAG POLE LIGHT: LED Other Fixture Unit 16W:	1	1	21	21
LED 4: OA: FULL CUTOFF WALLPACK: LED Other Fixture Unit 16W:	1	7	17	119
Total Tradable Proposed Watts =				742

Section 4: Requirements Checklist

- Lighting Wattage:**
- ☒ 1. Within each non-tradable area/surface, total proposed watts must be less than or equal to total allowed watts. Across all tradable areas/surfaces, total proposed watts must be less than or equal to total allowed watts.
Compliance: Passes.

Controls, Switching, and Wiring:

Project Title:
Data filename: F:\2017 projects\OCAC\Comcheck - OCAC Parking Lot addition.cck
Report date:
Page 1 of 2

- N/A** ☒ 2. All exemption claims are associated with fixtures that have a control device independent of the control of the nonexempt lighting.
- ☒ 3. Lighting not designated for dusk-to-dawn operation is controlled by either a a photosensor (with time switch), or an astronomical time switch.
- ☒ 4. Lighting designated for dusk-to-dawn operation is controlled by an astronomical time switch or photosensor.
- ☒ 5. All time switches are capable of retaining programming and the time setting during loss of power for a period of at least 10 hours.

Exterior Lighting Efficacy:

- ☒ 6. All exterior building grounds luminaires that operate at greater than 100W have minimum efficacy of 60 lumen/watt.

N/A Exceptions:

- ☒ Lighting that has been claimed as exempt and is identified as such in Section 3 table above.
- ☐ Lighting that is specifically designated as required by a health or life safety statute, ordinance, or regulation.
- ☐ Emergency lighting that is automatically off during normal building operation.
- ☐ Lighting that is controlled by motion sensor.

Section 5: Compliance Statement

Compliance Statement: The proposed exterior lighting design represented in this document is consistent with the building plans, specifications and other calculations submitted with this permit application. The proposed lighting system has been designed to meet the 2009 IECC requirements in COMcheck Version 4.0.5.2 and to comply with the mandatory requirements in the Requirements Checklist.

Nancy Kanter, LC Lighting Designer
Signature:  Date: 02-28-2017

Name : Title
Date

Project Title:
Data filename: F:\2017 projects\OCAC\Comcheck - OCAC Parking Lot addition.cck

Report date:
Page 2 of 2

McMahon provides this drawing as instruments of service. All rights are reserved. The client agrees to indemnify and hold McMahon harmless from and against all claims, damages, costs and expenses, including reasonable attorney's fees, arising from or due to McMahon's negligence in the performance of its professional services. This agreement shall survive the termination or completion of the contract.

REVISION

DATE

NO

ALTERATION / ADDITION
OUTAGAMIE COUNTY ADMINISTRATION CENTER
S. WALNUT & W. 8TH, APPLETON WI 54911
COMCHECK REPORT-SITE LIGHTING

DESIGNED
CEH
DRAWN
MAL
PROJECT NO.
00002-61600160
DATE
MARCH 3, 2017
SHEET NO.

ES802